



**NOTES:**  
 1. LOCATION OF CABLES ARE APPROXIMATE. CONTRACTOR SHALL LOCATE EXISTING UNDERGROUND CABLES AND INSTALL NEW CABLES IN PARALLEL WITHIN 1.5M.  
 2. THE 5KV CABLES SHALL BE TERMINATED AT SWITCHGEAR LOCATED IN DEACON BOOSTER PUMPING STATION BY THE CONTRACTOR. THE SWITCHGEAR IN DEACON BOOSTER PUMPING STATION WILL BE READY FOR THE CABLE TERMINATION IN DECEMBER 2007 / JANUARY 2008. COORDINATE THE SCHEDULE WITH THE CONTRACT ADMINISTRATOR

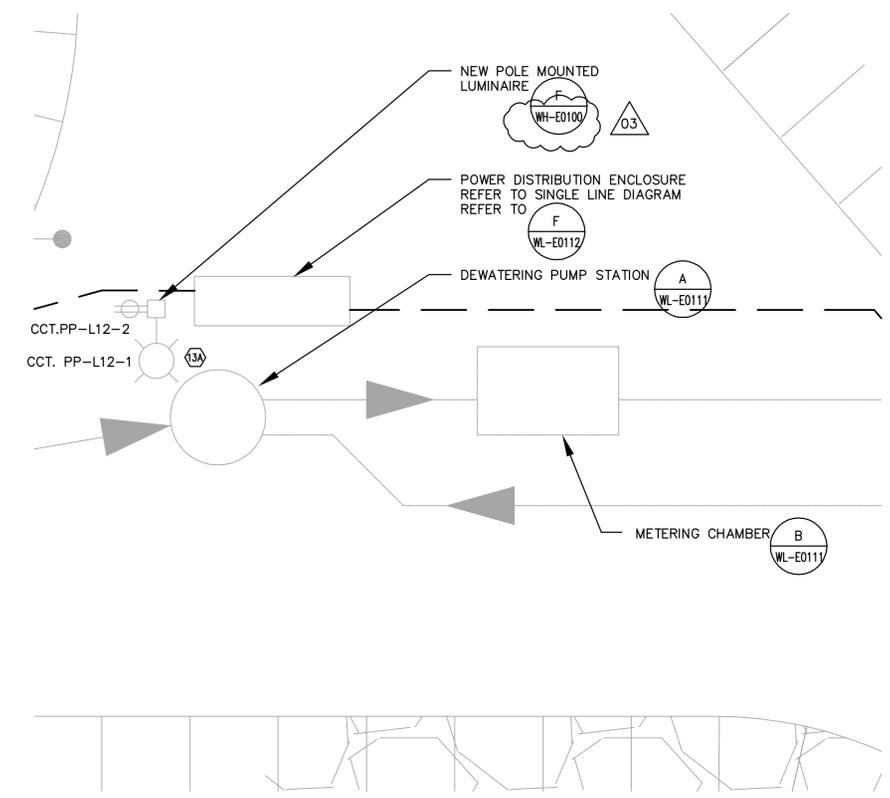

**PARTIAL SITE PLAN**  
1 : 2000

**A DETAIL**  
1 : 100

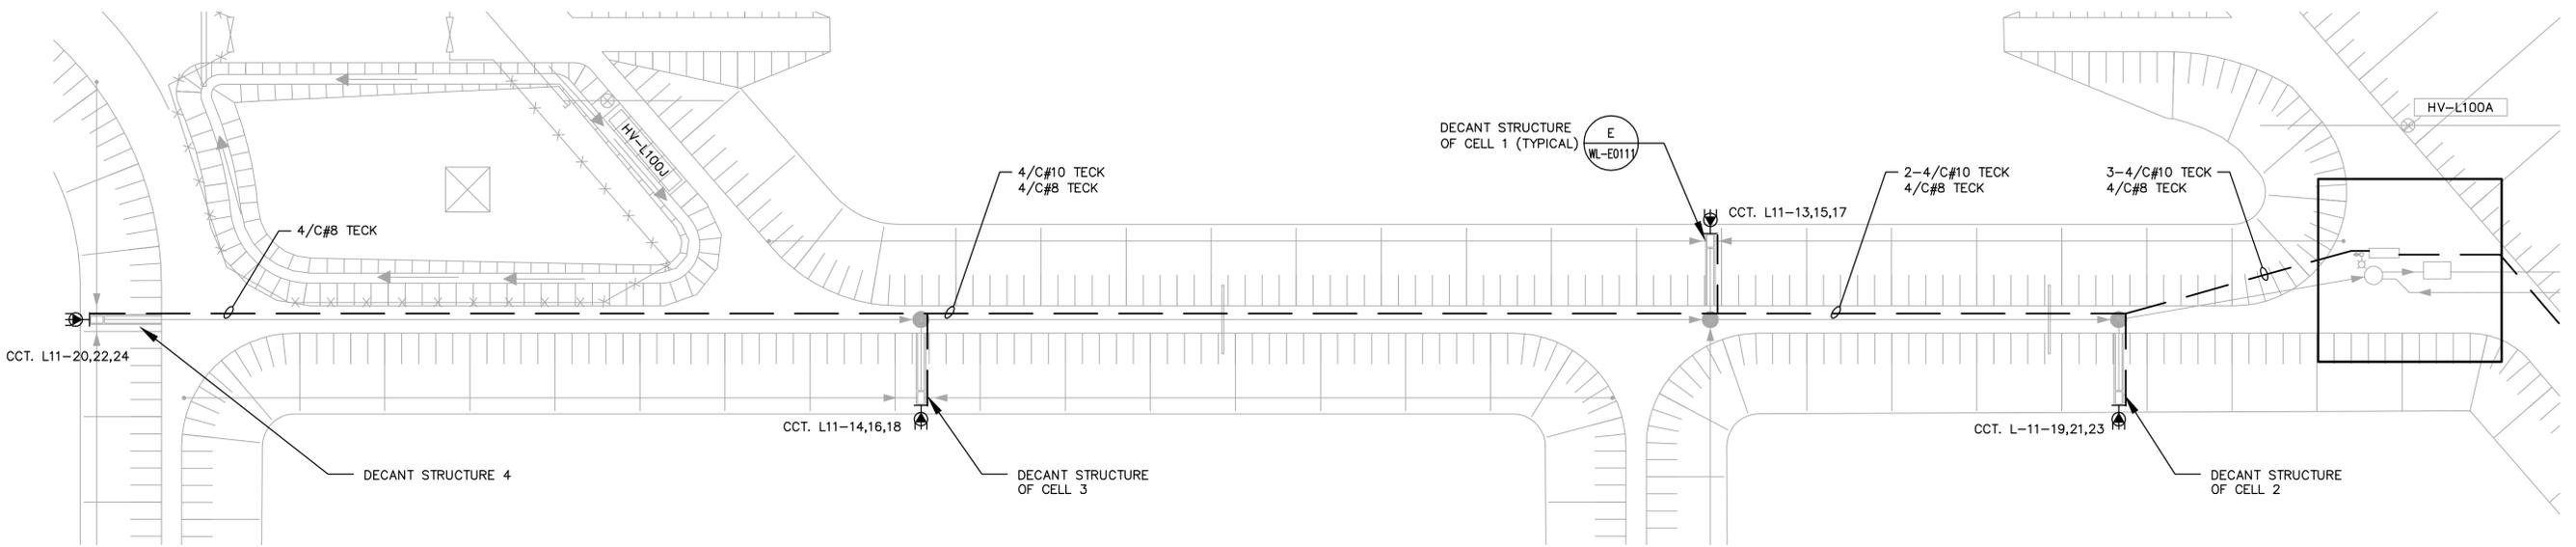

**B DETAIL**  
1 : 500

**APEGM**  
 Certificate of Authorization  
 Earth Tech Canada Inc.  
 No. 730 Expiry: April 30, 2007

NO.	REVISIONS	DATE	BY
03	94-2007 ADDENDUM 2	07/05/22	ERC
02	ISSUED FOR TENDER (94-2007)	07/02/20	ERC
01	ISSUED FOR CONSTRUCTION	06/06/06	JBC
00	ISSUED FOR TENDER	06/03/07	ERC

**CH2M HILL**  
 Frederickson Cooper  
 ARCHITECTS

**EarthTech**  
 A Tyco International Ltd. Company

DESIGNED BY	BLM	CHECKED BY	PS
DRAWN BY	ERC	APPROVED BY	DJT
SCALE:	AS SHOWN		
RELEASED FOR CONSTRUCTION BY:	R. SOROKOWSKI		
DATE	2006/01/03	DATE	06/03/07

ENGINEER'S SEAL  
 ORIGINAL SIGNED BY  
 B.L. MOORE  
 2006/03/07  
 CONSULTANT DRAWING NO.  
 WL-E0110

**THE CITY OF WINNIPEG**  
 WATER AND WASTE DEPARTMENT  
 ENGINEERING DIVISION

WATER TREATMENT PLANT  
 CONSTRUCTION OF DEWATERING CELLS

ELECTRICAL  
 DECANT SYSTEMS  
 PLANS AND DETAILS

CITY FILE NUMBER	
SHEET	OF
CITY DRAWING NUMBER	1-0601L-A-E0110-001-03D