


	B.M. ELEV.			SEarthTech A Tyco International Ltd. Company			ENGINEER'S SEAL ORIGINAL SIGNED BY	
				DESIGNED BY DRAWN	GSN	CHECKED BY APPROVED	PS	P. STRYK 2006/04/26
02		06/09/22 06/05/19		BY HOR. SCALE:	NTS	BY JEH RELEASED FOR CONSTRUCTION BY: J. VEILLEUX DATE 2006/04/26		-
00 NO	ISSUED FOR TENDER	06/04/26 DATE		DATE 200	E: 5/11/22			CONSULTANT DRAWN

Certificate of Authorization Earth Tech Canada Inc.

No. 730 Expiry: April 30, 2006

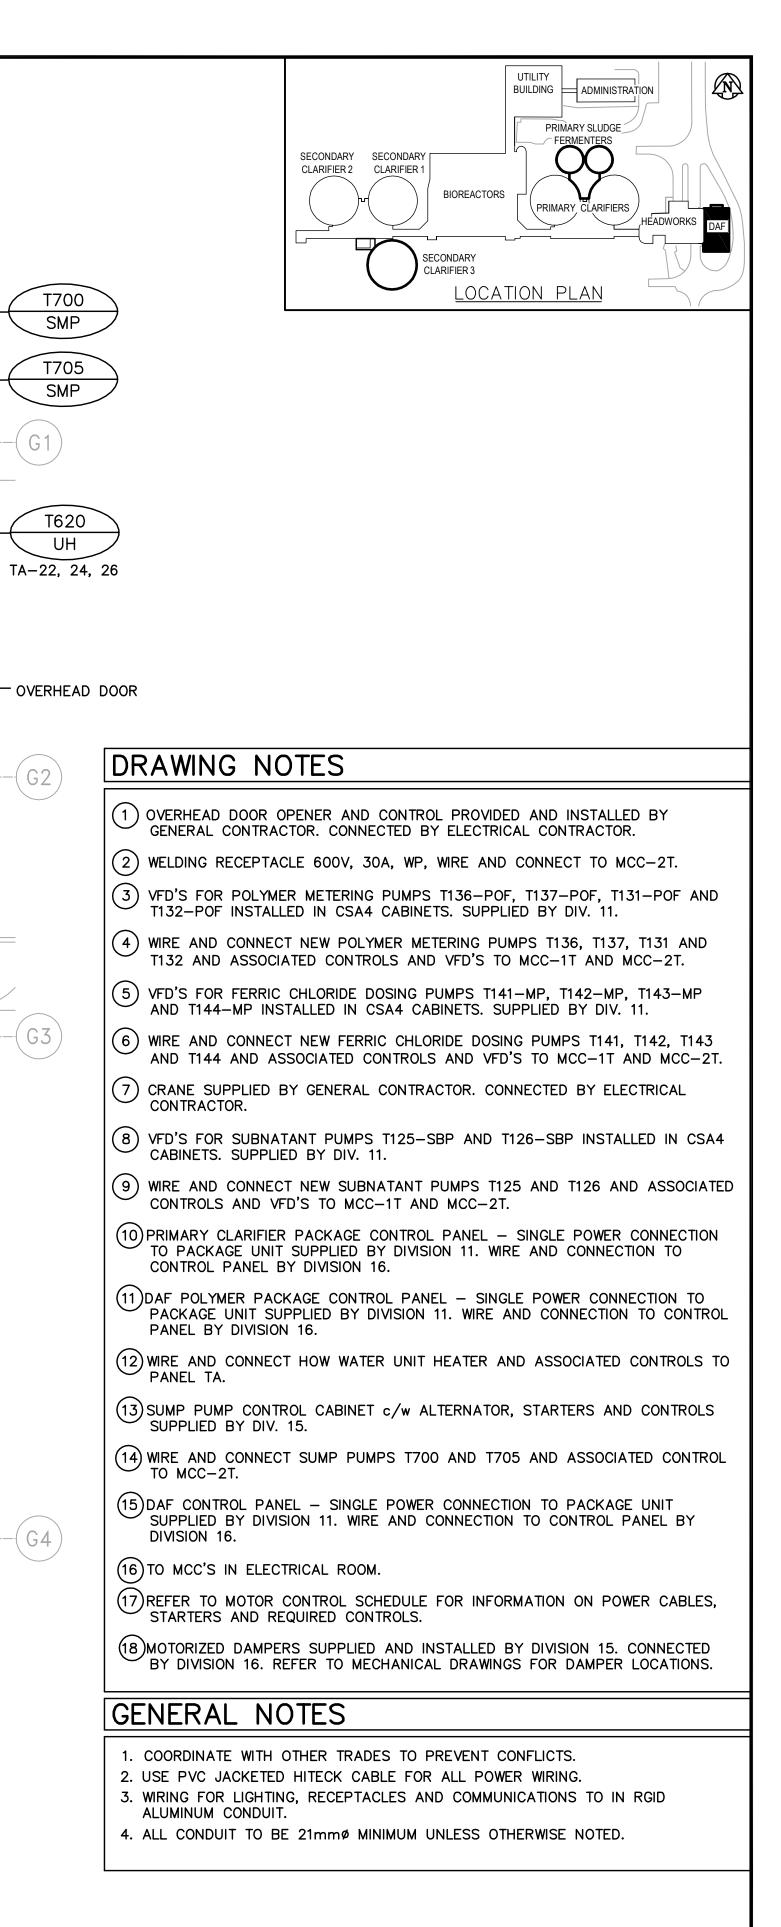

ORIGINAL SIGNED BY	Winnipeg THE CITY OF WINNIPEG WATER AND WASTE DEPARTMENT ENGINEERING DIVISION							
P. SIRTK	WEWPCC	CITY FILE NUMBER						
2006/04/26	BIOLOGICAL NUTRIENT REMOVAL UPGRADE CONTRACT 3	SHEET OF						
	ELECTRICAL	CITY DRAWING NUMBER						
SULTANT DRAWING NO.	AREA T – DAF THICKENER BUILDING							
TE1.02	MAIN FLOOR POWER PLAN							