

THE CITY OF WINNIPEG PLANNING,
PROPERTY AND DEVELOPMENT
DEPARTMENT
MUNICIPAL ACCOMMODATIONS DIVISION 4TH FLOOR - 185 KING STREET R3B 1J1

Project: St. Vital Library

3. PAINT ALL JUNCTION BOXES TO MATCH EXISTING COLOUR CODING OF BUILDING SYSTEMS.

4. WIRE AND CONNECT NEW TYPE A, B & G LUMINAIRES TO EXISTING CIRCUIT AND CONTROL. CONFIRM EXISTING ON SITE.

6 Fermor Ave. Winnipeg Manitoba

Project Number: 16054 Bid Opportunity Number: 768-2016 Drawing Title: NEW MAIN FLOOR LIGHTING PLAN

Issue/Revision Date

ISSUED FOR CONSTRUCTION


ADDENDUM #1 OCT 31, 2016

APEGIN Certificate of Authorization Sheet No: E-9

HDK Consulting Incorporated

No. 5539 Date: 04/30/2017

This drawing is property of the Architect and cannot be reproduced or used without the consent of the Architect. The contractor is responsible for checking and verifying all levels and dimensions and shall report all discrepancies to the Architect and obtain clarification prior to commencing work.

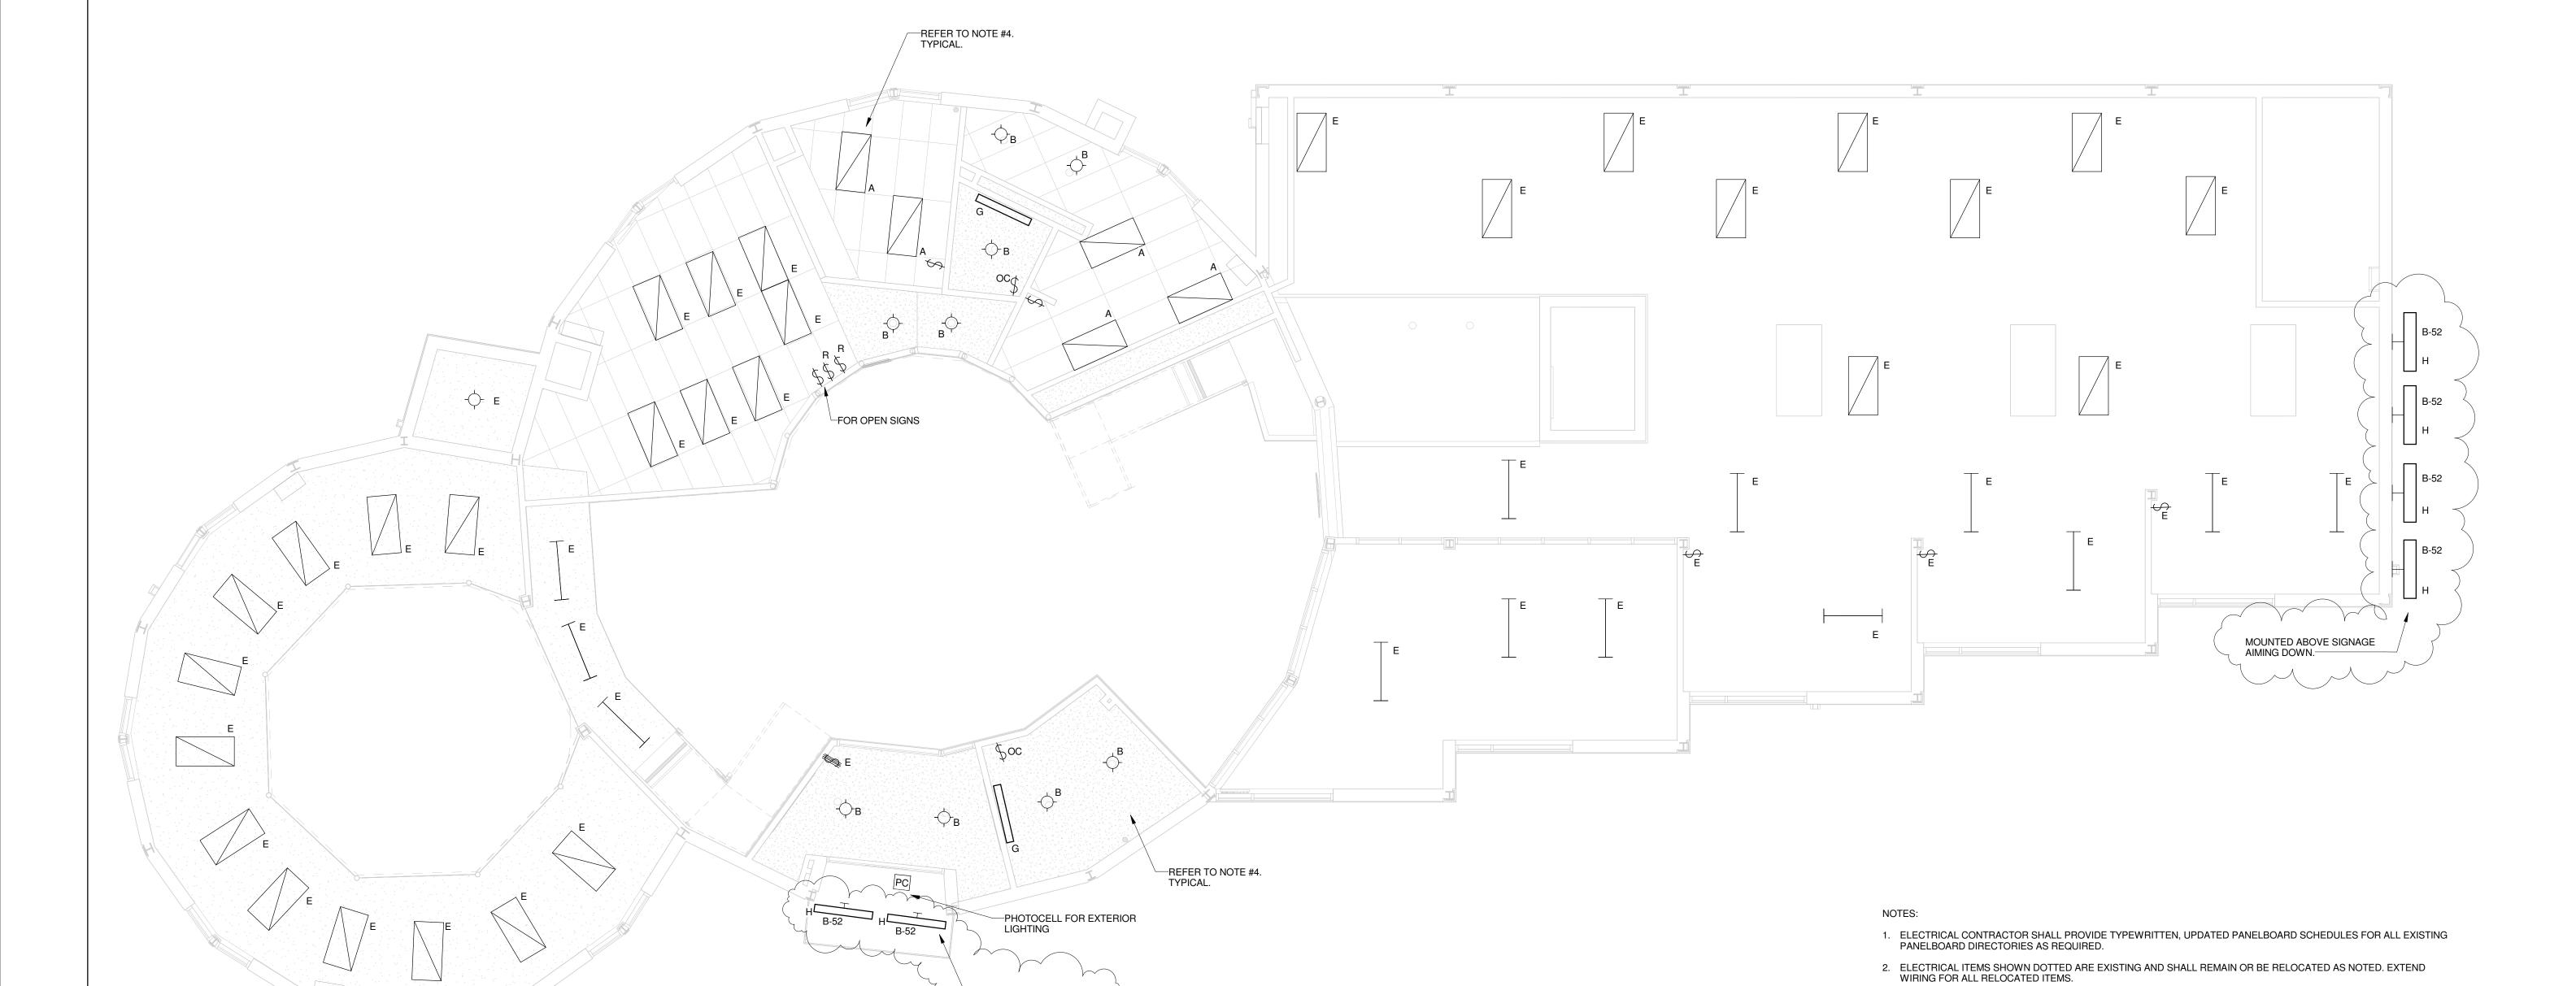

MOUNTED BELOW SIGNAGE AIMING UP.

NEW MAIN FLOOR LIGHTING PLAN
3/16" = 1'-0"