



KEY NOTES

- 1 OVERHEAD LINES AND POLE TO BE DEMOLISHED BY MB HYDRO.
- 2 DEMOLISH MP-1, PP-1 AND MS-1 THRU 3. COORDINATE DEMOLITION WORK WITH MB HYDRO. MAINTAIN EXISTING SYSTEM IN SERVICE UNTIL NEW SYSTEM IS COMPLETE AND READY FOR SERVICE.
- 3 EXISTING GOLF COURSE IRRIGATION PUMP DISCONNECT FROM MS-3. EXTEND FEEDER TO NEW SOURCE MDB-1 LOCATED IN 2ND FLOOR MECH/ELEC ROOM.

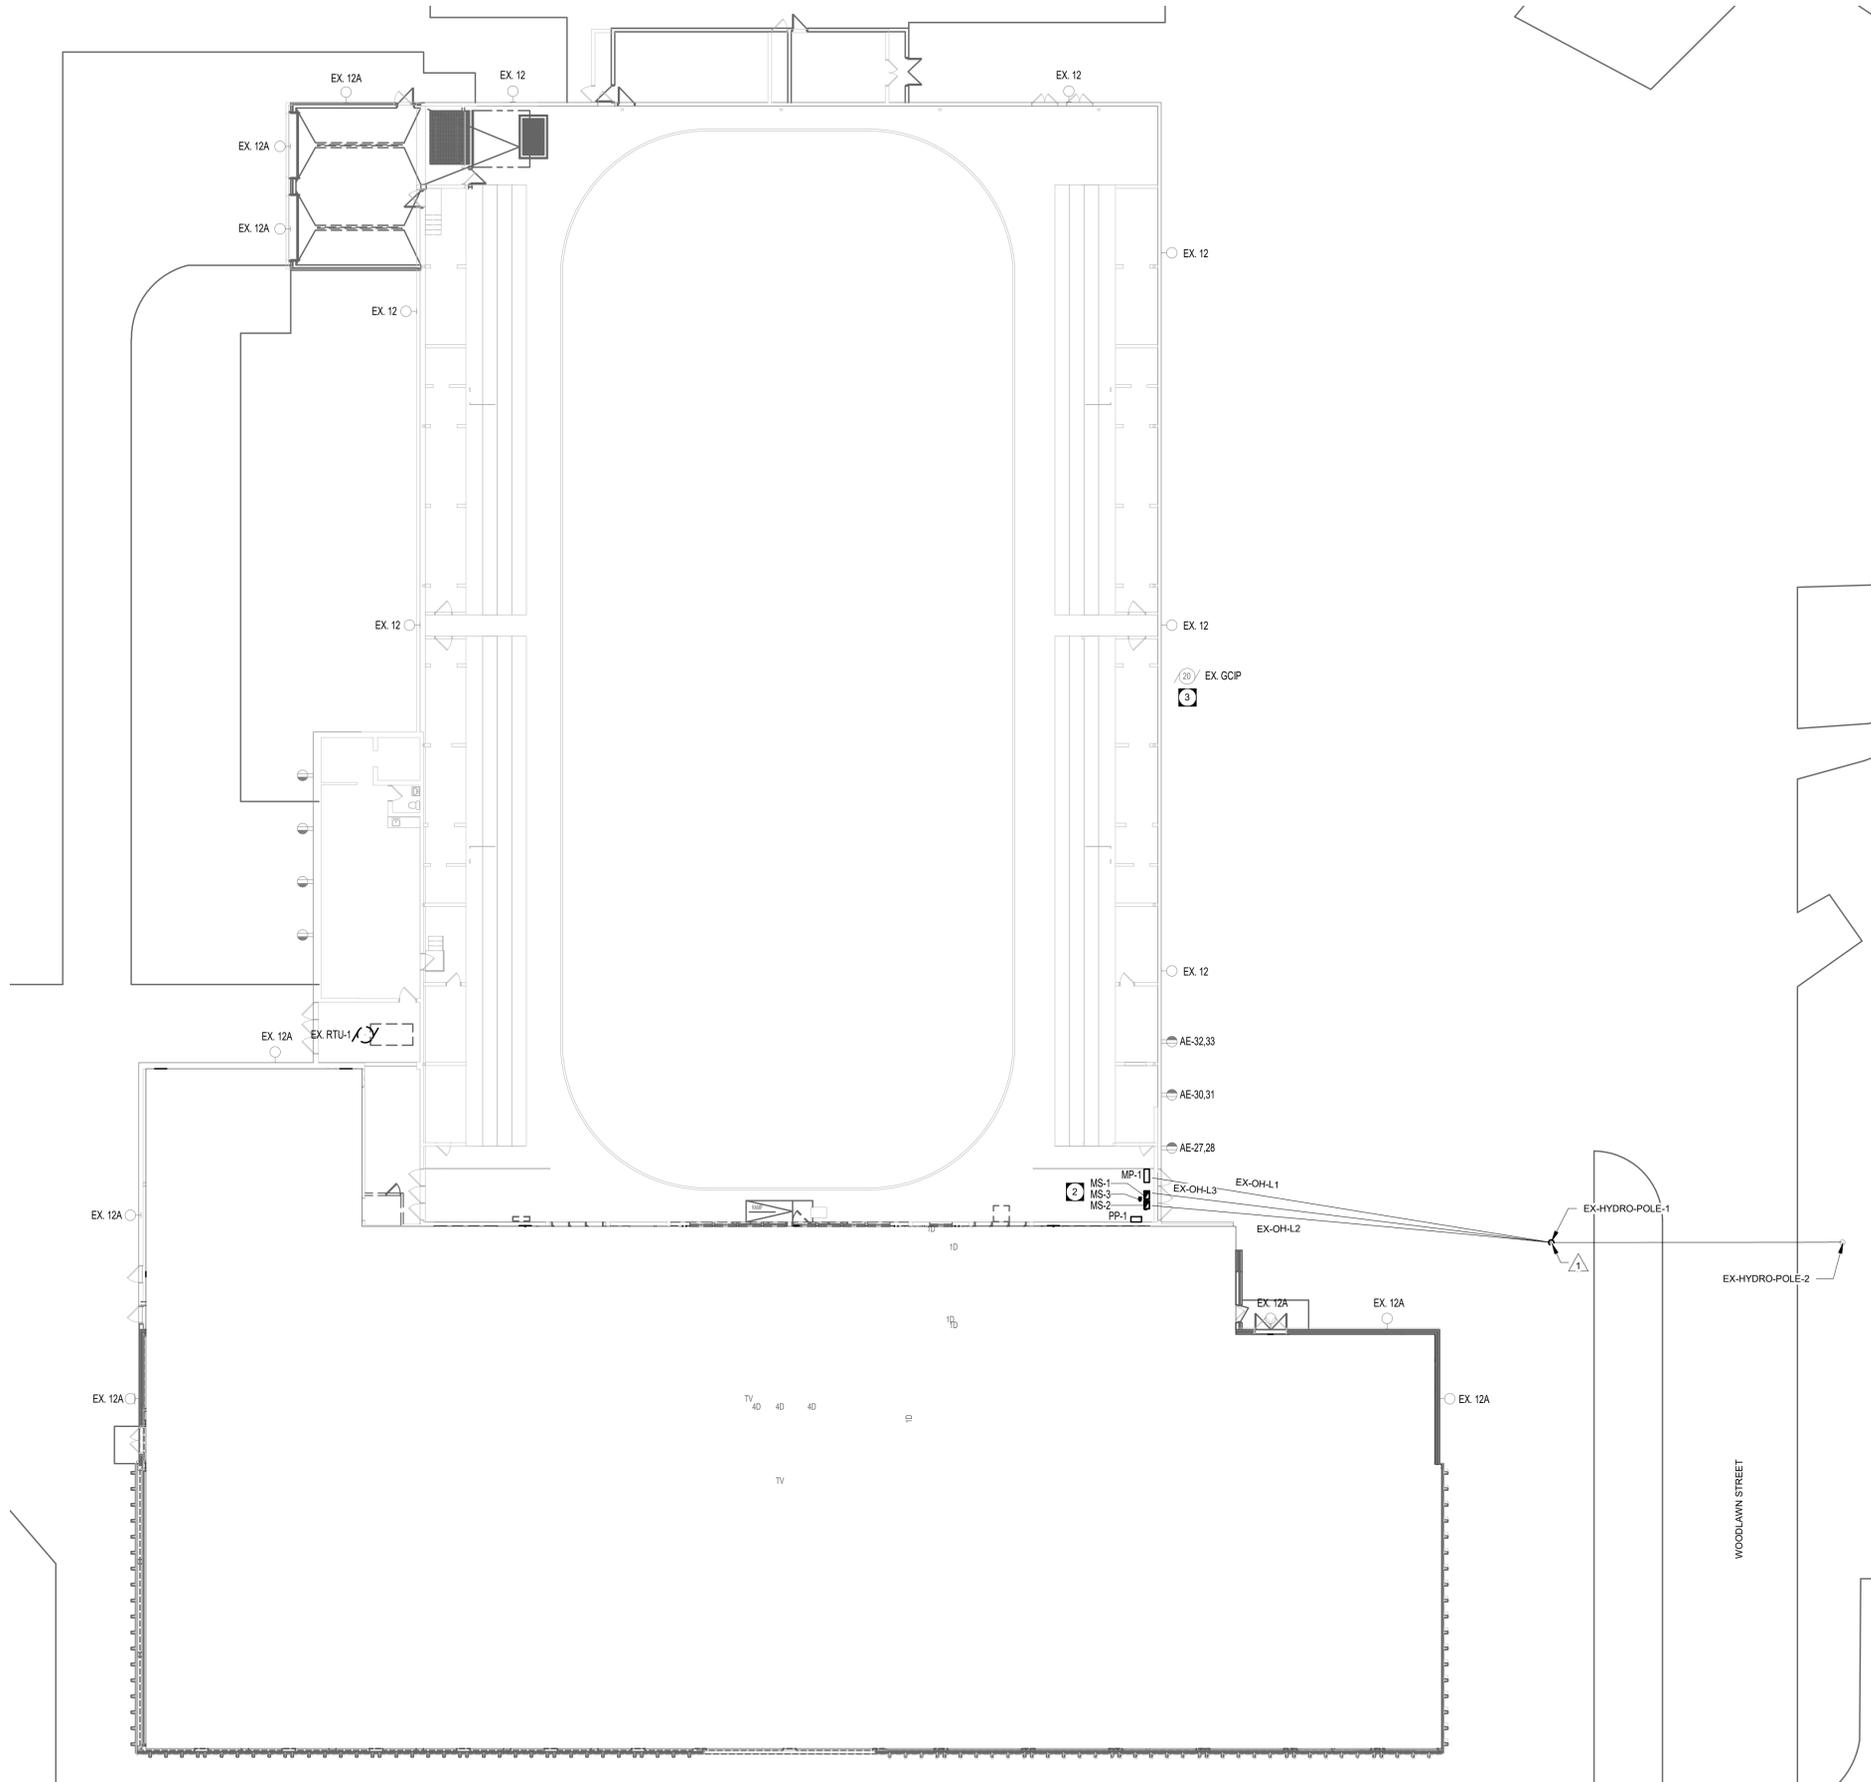

This is a print of a document that has been electronically authenticated with technology authorized by the APEGM. The original is in electronic form.

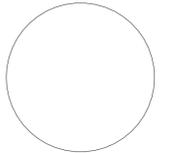

This drawing must not be scaled. The contractors shall verify all dimensions and other data on site prior to commencement of work. Discrepancies, errors, and omissions are to be reported to Public City Architecture Inc. prior to proceeding with the Work.

Drawings and specifications as instruments of service are the property of Public City Architecture Inc. the copyright in the same being reserved. No reproduction or revision to these drawings may be made without the permission of Public City Architecture Inc. and when made, must bear their name. All prints to be returned to Public City Architecture Inc. upon request.

Project
ST. JAMES CIVIC CENTRE

Drawing
ELECTRICAL SITE PLAN - DEMOLITION

Drawn By: JA Review By: MP
 Scale: 1/16" = 1'-0" Tender No: 1176-2019
 Date: 11/06/19
 Sheet: **E1.1**