

KEY NOTES


- 1 FIRE PROTECTION MAINS DOWN FROM ABOVE TO SERVE LOW LEVEL CHANGE ROOMS.

PUBLICCITY

Public City Architecture Inc
11-600 Clifton Street
Winnipeg, Manitoba
R3G 2X6 204 475 9323
publiccityarchitecture.com


Rev. No. Date Revision Notes

0 19-11-06 Issued for Construction

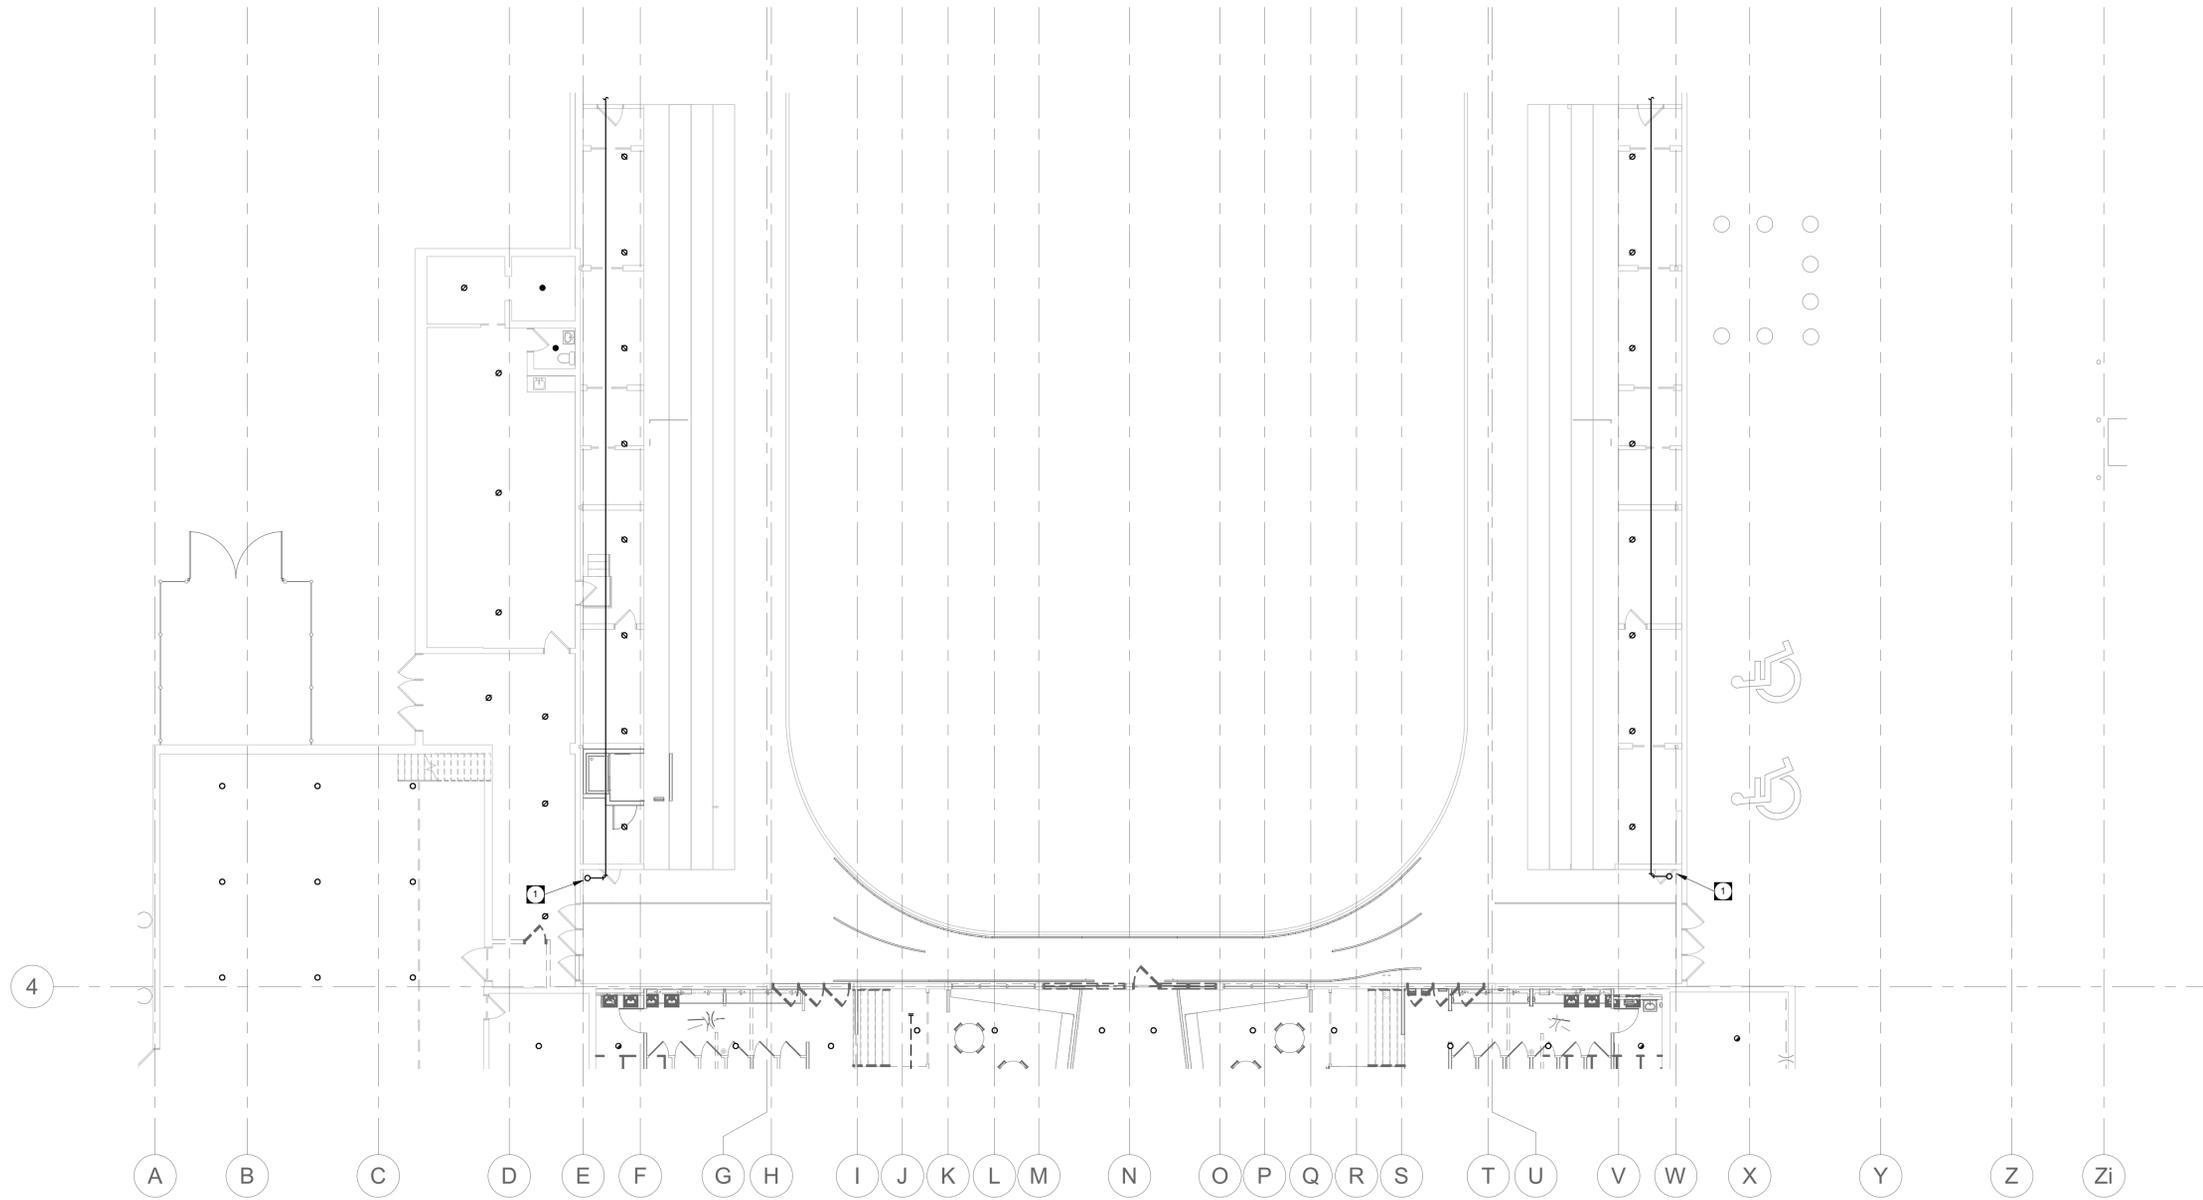

APEGM
Certificate of Authorization
Epp Siepmann Engineering Inc.
No. 4035

This is a print of a document that has been electronically authenticated with technology authorized by the APEGM. The original is in electronic form.

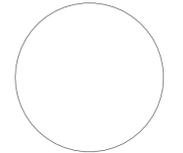

This drawing must not be scaled. The contractors shall verify all dimensions and other data on site prior to commencement of work. Discrepancies, errors, and omissions are to be reported to Public City Architecture Inc. prior to proceeding with the Work.
Drawings and specifications as instruments of service are the property of Public City Architecture Inc. the copyright in the same being reserved.
No reproduction or revision to these drawings may be made without the permission of Public City Architecture Inc. and when made, must bear their name. All prints to be returned to Public City Architecture Inc. upon request.

ARENA SOUTH LOW LEVEL - FIRE PROTECTION RENOVATION 1
3/32" = 1'-0" MF2.5

Project
ST. JAMES CIVIC CENTRE

Drawing
ARENA SOUTH - FIRE PROTECTION PLAN

Drawn By: DK Review By: JS
Scale: 3/32" = 1'-0" Tender No: 1176-2019
Date: 11/06/19
Sheet: MF2.5