

**GENERAL NOTES:**

 

1. GREY LINEWEIGHT DENOTES EXISTING, BOLD DENOTES NEW.

**KEYNOTES:**

1. INSTALL NEW CIRCUIT BREAKERS IN EXISTING MCC. REFER TO DRAWING REFERENCE 1 FOR DETAILS.
2. APPROXIMATE LOCATION OF LOW WATER CUT-OUT (LWCO) SWITCH. WIRE AND CONNECT TO BOILER CONTROL CIRCUIT. THE LWCO SHALL BE WIRED IN SERIES WITH THE BOILER FLOW SWITCH 24VAC BURNER CONTROL CIRCUIT. WIRE AND CONNCT 120VAC LWCO SUPPLY VOLTAGE TO BOILER 120V TERMINALS. ALL FIELD DEVICES AND WIRING CONNECTIONS SHALL BE INSTALLED IN ACCORDANCE WITH BOILER MANUFACTURER'S INSTALLATION INSTRUCTIONS.
3. PROVIDE RED TOGGLE SHUTDOWN SWITCH FOR BOILER. WIRE AND CONNECT TO BOILER SHUTDOWN CONTROL CIRCUIT. ALL WIRING CONNECTIONS SHALL BE INSTALLED IN ACCORDANCE WITH BOILER MANUFACTURER'S INSTALLATION INSTRUCTIONS.
4. CARBON MONOXIDE DETECTION CONTROLLER AND CO SENSOR SHALL BE MOUNTED 1524mm ABOVE FINISHED FLOOR.

**LEGEND:**

-  SURFACE MOUNTED PANELBOARD
-  FIELD DEVICE
-  MOTOR STARTER
-  MOTOR
-  EQUIPMENT LOAD
-  SPECIAL POWER OUTLET

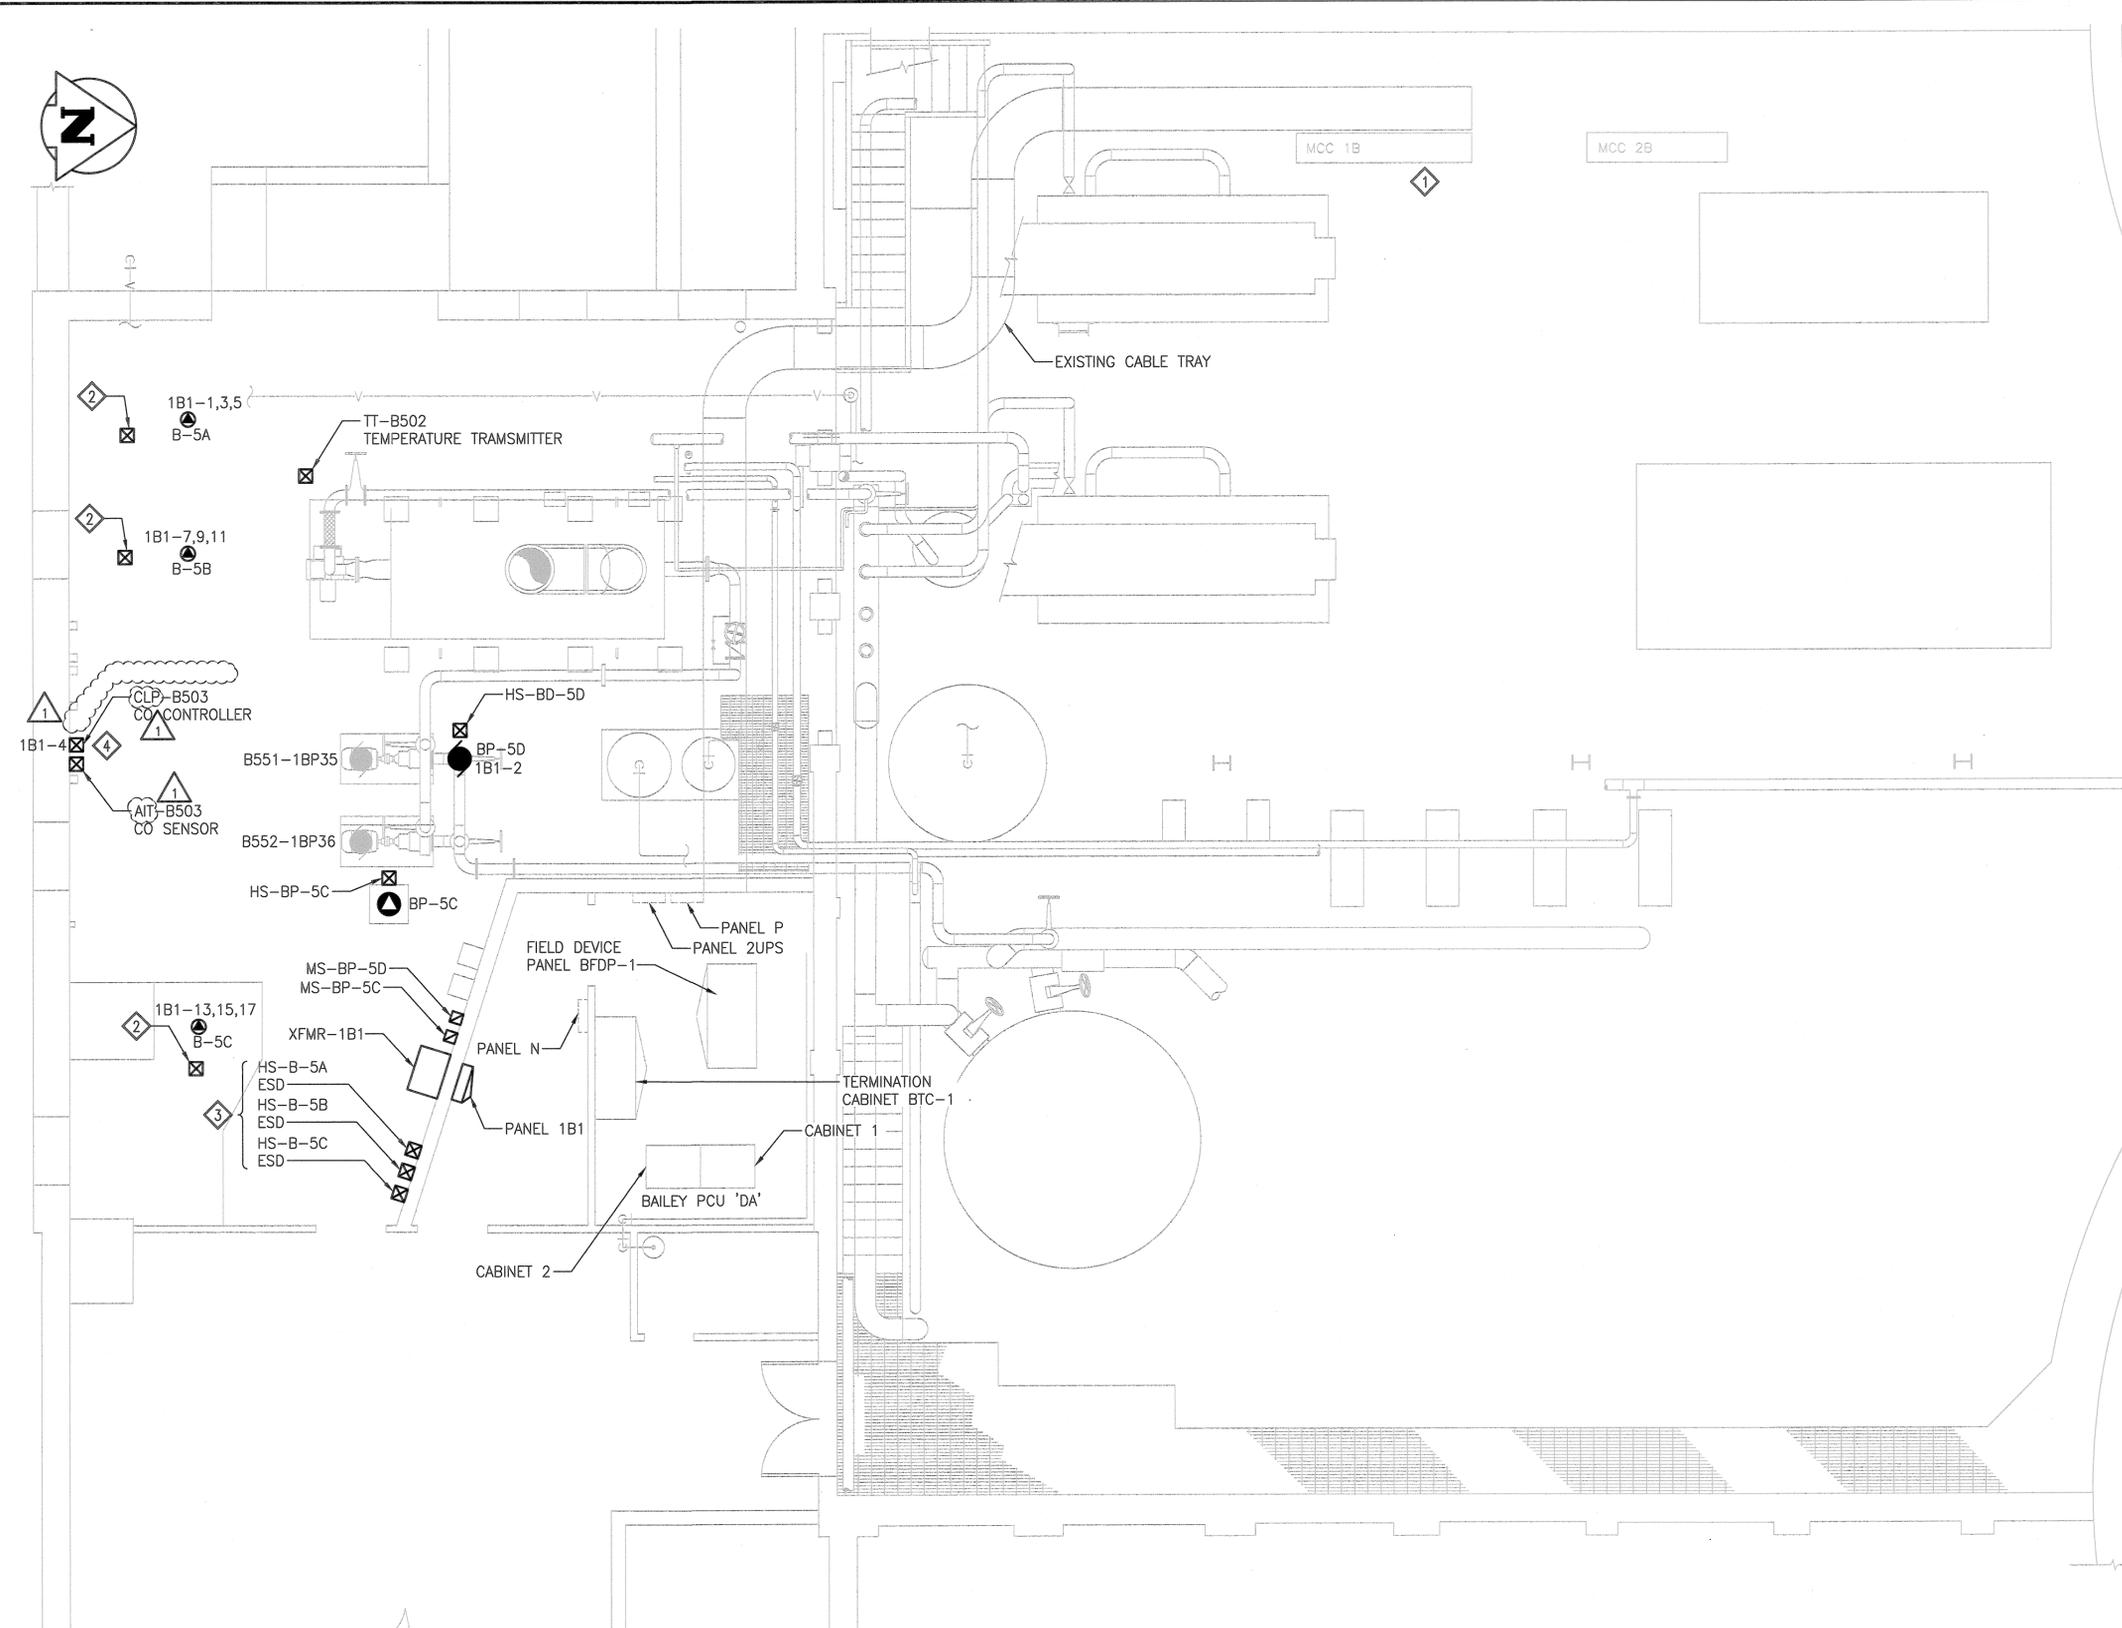

10		
9		
8		
7		
6		
5		
4		
3		
2		
1	23-0107-010_E0.02	AREA B - BOILER ROOM SINGLE LINE DIAGRAM ELECTRICAL DISTRIBUTION
NO.	DRAWING NUMBER	REFERENCE DRAWING TITLE
REFERENCE DRAWINGS		

TEMPORARY

B.M. ELEV.	
CONSTRUCTION COMPLETION DATE: YYYY MM DD	
DESIGNED BY	TB
CHECKED BY	DDW
DRAWN BY	DIS
APPROVED BY	TB
SCALE:	AS SHOWN
RELEASED FOR CONSTRUCTION	
DATE	2023 09 11
DATE	
NO.	REVISIONS
1	RE-ISSUED FOR CONSTRUCTION 2023 10 18
0	ISSUED FOR CONSTRUCTION 2023 10 05
NO.	REVISIONS
DATE	BY
DATE	2023 10 18

**KGS GROUP**

ENGINEER'S SEAL



2023-10-18

CONSULTANT DRAWING NUMBER

23-0107-010\_E1.01

BID OPPORTUNITY: 792-2023  
CONTRACT NUMBER:

**THE CITY OF WINNIPEG**  
WATER AND WASTE DEPARTMENT  
ENGINEERING DIVISION

**Winnipeg**

NORTH END SEWAGE TREATMENT PLANT (NEWPC)  
INTERIM BACKUP BOILER SYSTEM  
AREA B - BOILER ROOM

ELECTRICAL  
EQUIPMENT LAYOUT

CITY DRAWING NUMBER

SHEET 1 OF 1

ENGINEERS  
GEOLOGISTS  
MANITOBA  
Certificate of Authorization  
KGS Group  
No. 245