

PLAN LEVEL 200 1

mm SCALE 1:50

E0009

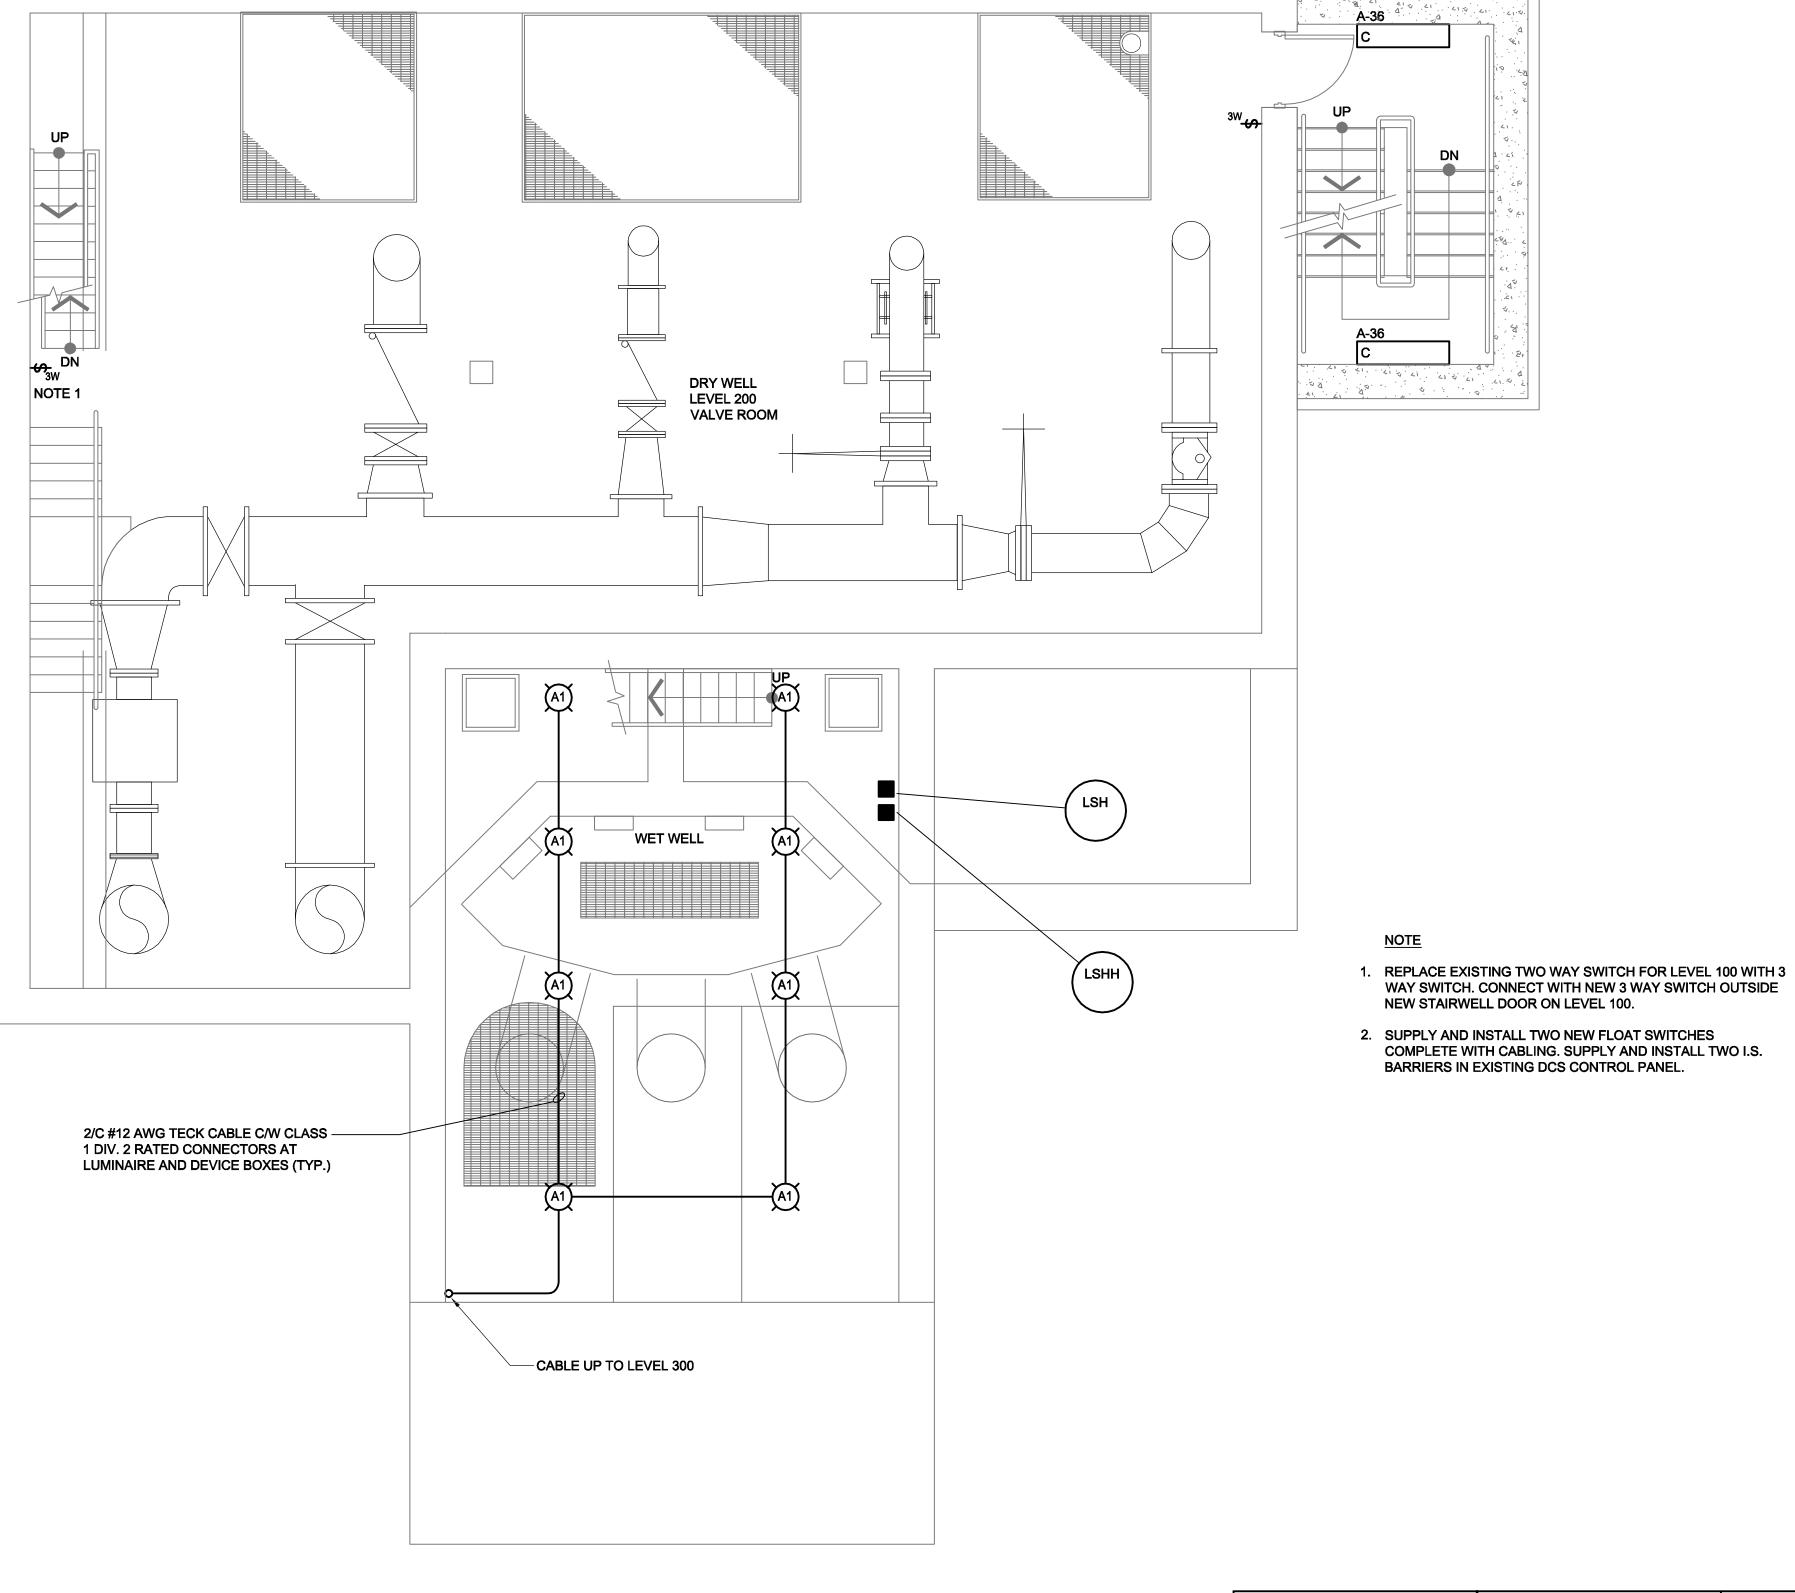

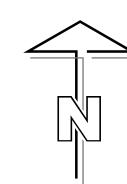

Certificate of Authorization

UMA Engineering Ltd. (MB)

No. 256 Date: 07/12/14

QL	RS	вм	вм	BF
DRN	CHK	DES	ENG	IDR
	UM	A REVI	EW	

B.M. ELEV.		FIELD BOOK #:					ENGINEER'S SEAL	
_	POSTED TO LBIS				UMA		AECOM	
					© 2006 UMA ENGINEERING LTD. ALL RIGHTS RESE		G LTD. ALL RIGHTS RESERVED.	ISSUE / REVIS
					DESIGNED	BM/LK	CHECKED	ISSUED FOR
					BY		BY	WAS SEALE
					DRAWN BY	SCK	APPROVED _	B.L. MOO
D	ISSUED FOR BID		07/12/14	LJV	HOR. SCALE AS NOTED VERTICAL AS NOTED		55151655 565	AND DAT 07/12/14
С	ISSUED FOR 100% REVIEV	V	07/11/09	SCK			CONSTRUCTION	
В	ISSUED FOR ZONING		07/08/21	SCK				4
Α	ISSUED FOR 80% REVIEW		07/06/18	SCK	DATE O	7/05/09	DATE	
NO.	REVISIONS	_	DATE	BY	FILENAME: D265-202-02_02-E-0201_RX.dwg			

ISSUE / REVISION D	
ISSUED FOR BID	
WAS SEALED BY	
B.L. MOORE	
AND DATED	
07/12/14	

Winnipeg WATER AND WASTE DEPARTMENT

PERIMETER ROAD PUMPING STATION UPGRADES Contract B - Building Upgrades

Electrical - Lighting Layout LEVEL 200 FLOOR PLAN

SHEET REV. SIZE DOTE D 1-0111L-E0008