


1 FLOOR PLAN  
A2 Scale: 1:25



2 ROOF PLAN  
A2 Scale: 1:25

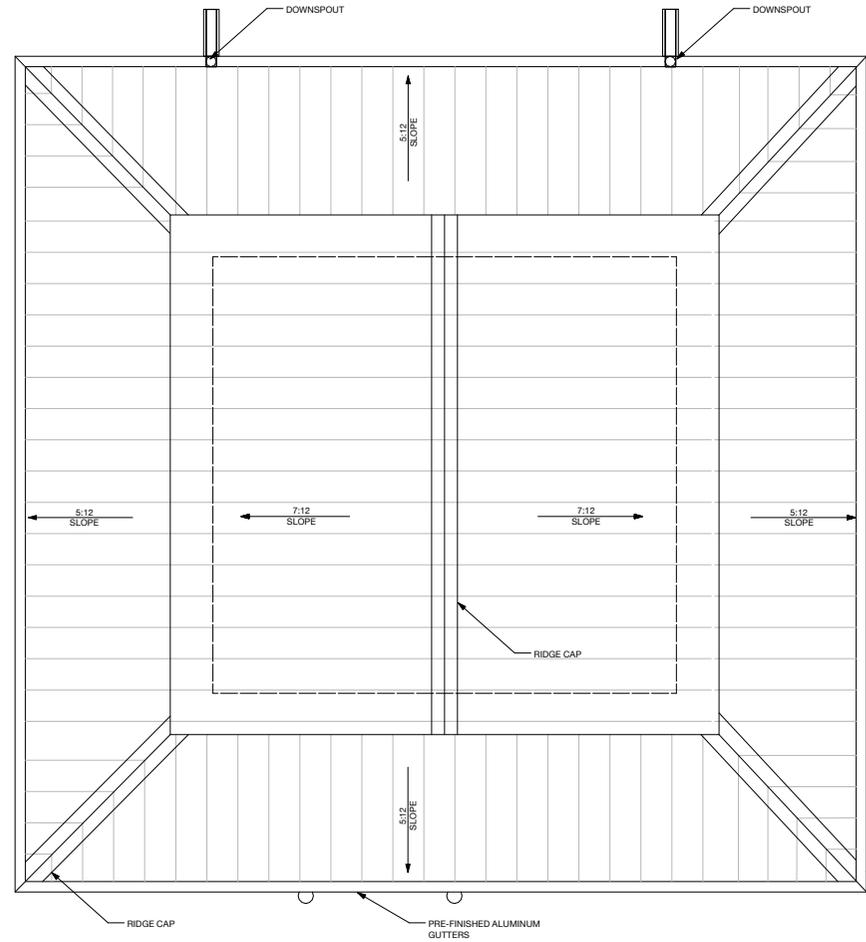

A = DETAIL/SECTION No.  
B = DRAWING WHERE SHOWN  
C = DRAWING WHERE TAKEN

NO.	REVISIONS	DATE	BY

**SYVERSON MONTEYNE**  
ARCHITECTURE

www.sm-arc.com  
p-204.947.3156 f-204.947.3161 807-70 Arthur St Winnipeg, MB

DESIGNED BY	DSy	CHECKED BY	EN
DRAWN BY	CWS AP	APPROVED BY	DSy

HOR. SCALE AS SHOWN  
VERTICAL AS SHOWN

RELEASED FOR CONSTRUCTION signed by K. Zurek  
DATE 2008 12 11 DATE 2009 03 27

ARCHITECT'S SEAL

BID OPPORTUNITY 901 - 2008  
PLOT DATE: 2009 03 26

**THE CITY OF WINNIPEG**  
WATER AND WASTE DEPARTMENT

REHABILITATION OF BOURNAIS WASTEWATER PUMPING STATION

CONSULTANT DRAWING NUMBER **A2.0**  
SHEET 2 OF 14  
CITY DRAWING NUMBER **8747**

MAIN FLOOR AND ROOF PLANS