



 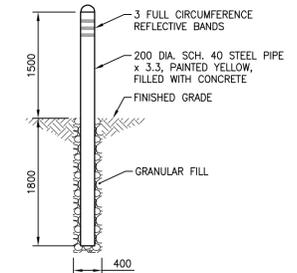


MAZENOD ROAD

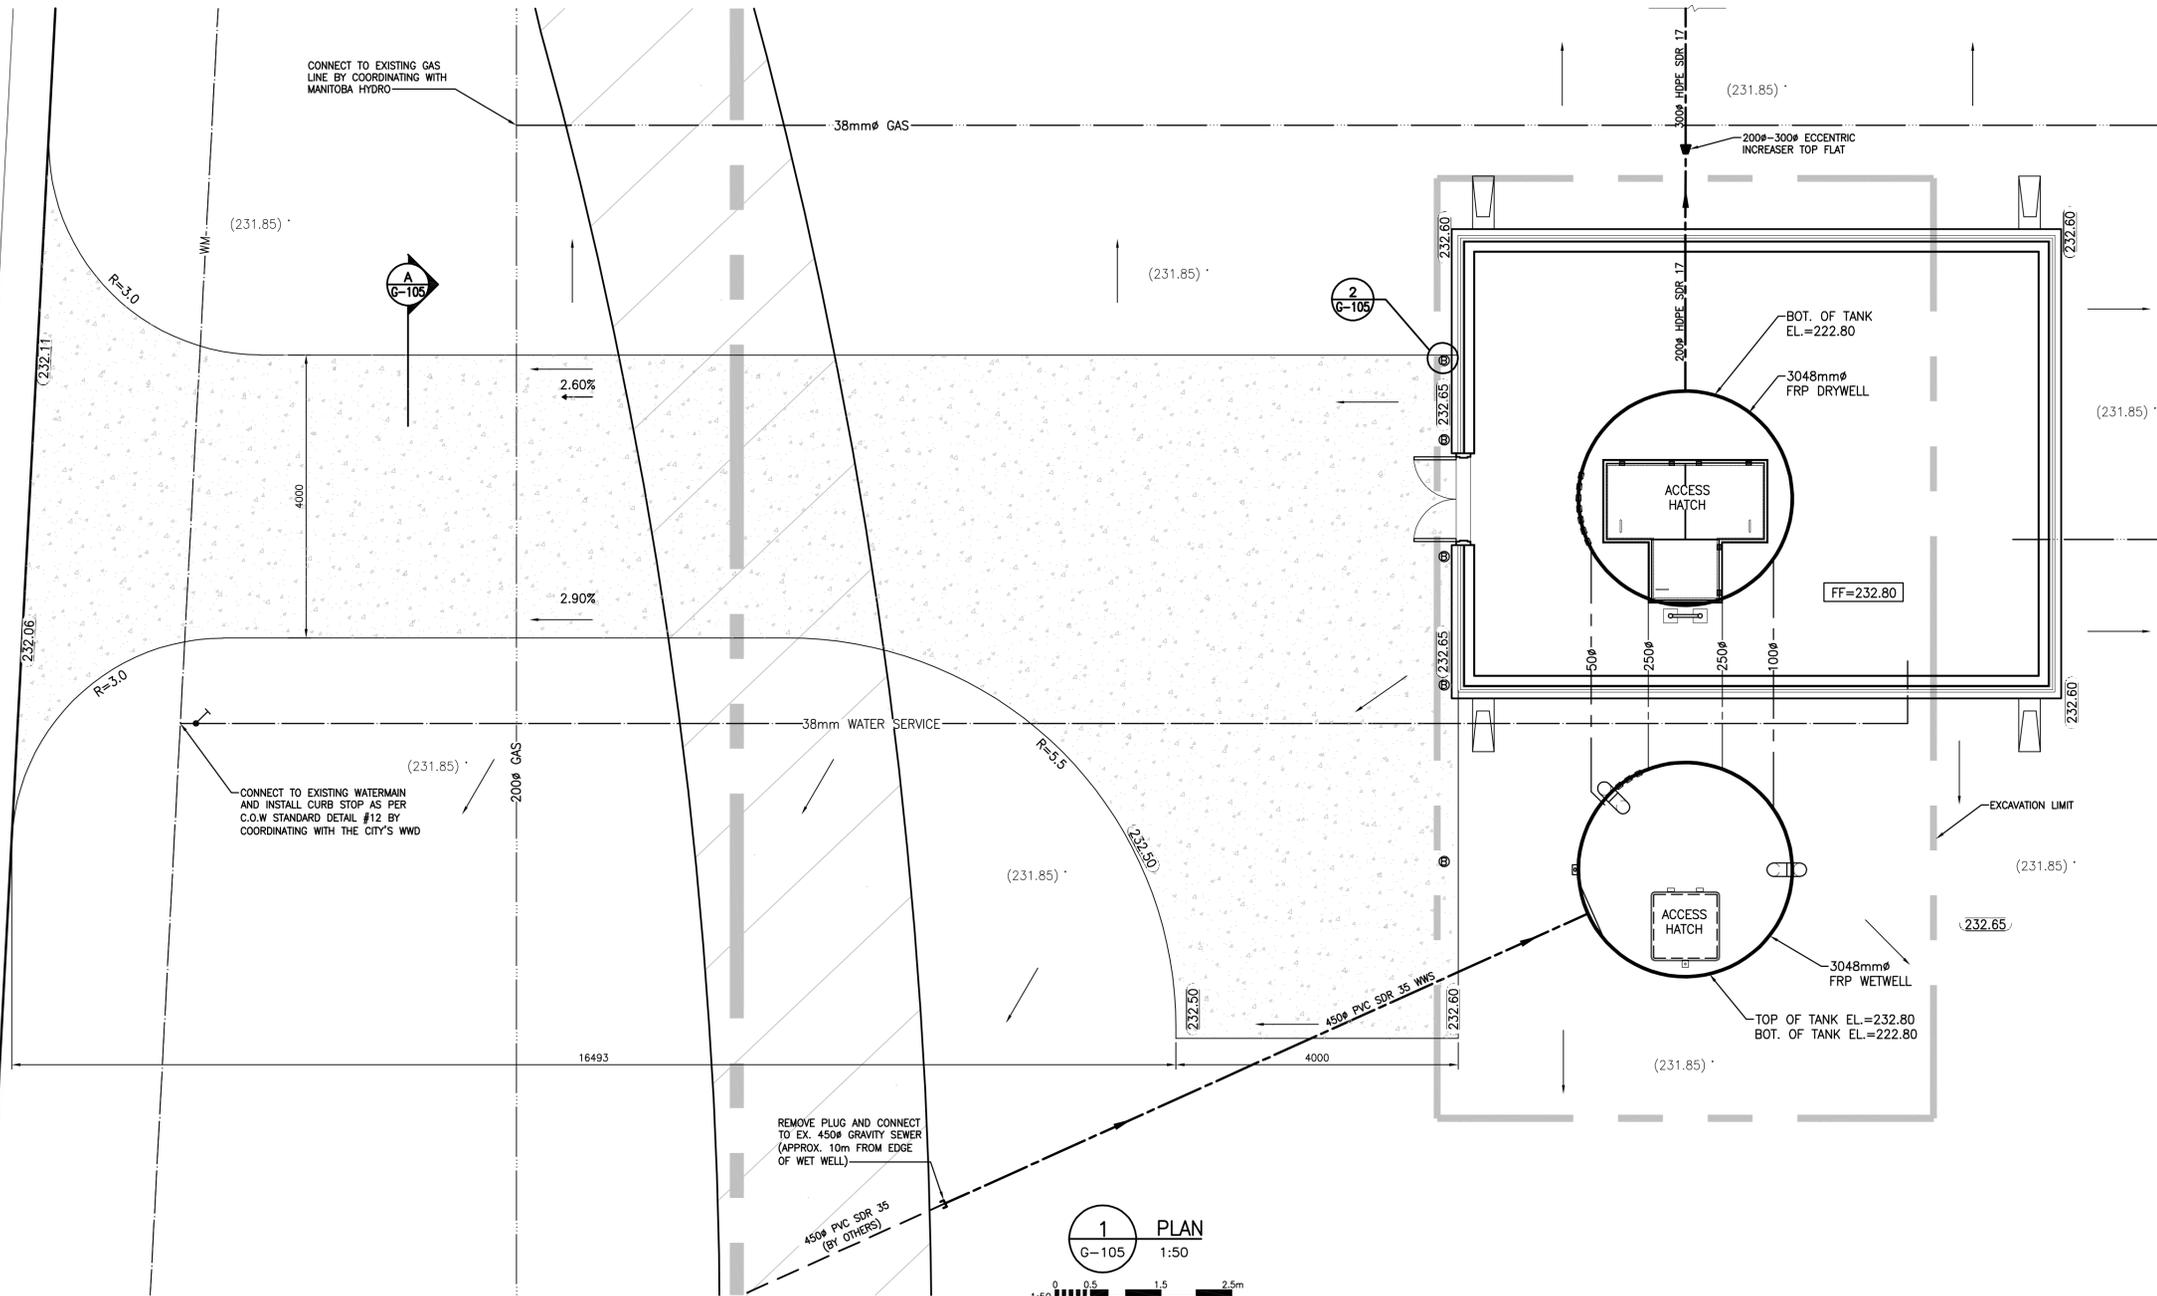

2 BOLLARD DETAIL
G-105 1:50

1 PLAN
G-105 1:50



A SECTION
G-105 N.T.S.

EXISTING	LEGEND	PROPOSED
⊗	VALVE	⊗
— 300 FM —	FORCEMAIN	— 300 FM —
— 450 WWS —	WASTE WATER SEWER	— 450 WWS —
—	PROPERTY LINE	—
—	CURB STOP	—
(247.62)	ELEVATION	46.250
— x — x —	FENCE	— x — x —
⊙	BOLLARD	⊙
⊙	TREES	⊙
⊙	TEST HOLE	⊙
→	FLOW DIRECTION	→
—	CONCRETE	—

LOCATION APPROVED UNDERGROUND STRUCTURES

SUPV. U/G STRUCTURES COMMITTEE DATE
NOTE: LOCATION OF UNDERGROUND STRUCTURES AS SHOWN ARE BASED ON THE BEST INFORMATION AVAILABLE BUT NO GUARANTEE IS GIVEN THAT ALL EXISTING UTILITIES ARE SHOWN OR THAT THE GIVEN LOCATIONS ARE EXACT. CONFIRMATION OF EXISTENCE AND EXACT LOCATION OF ALL SERVICES MUST BE OBTAINED FROM THE INDIVIDUAL UTILITIES BEFORE PROCEEDING WITH CONSTRUCTION.

BENCHMARK: N.W. Cor. of Mazenod Rd. & G.W.W.D. R.O.W., 19 mm dia. x 4.6 m I.B. in Valve Box, 3.0 m W. of W.L. of Mazenod Rd. & 4.0 m N. of N. rail of tracks in G.W. W.D. R.O.W.

B.M. 32-005	ELEV. 231.677
2	ISSUED FOR TENDER 15.12.23 M.H.
1	ISSUED FOR 95% REVIEW 15.12.04 M.H.
NO. REVISIONS	YY.MM.DD. BY

Stantec
500 - 311 Portage Avenue, Winnipeg M8 Canada R3B 2B9
Tel. 204.489.5900 Fax. 204.453.9012 www.stantec.com

DESIGNED BY	M.H.	CHECKED BY	R.G.
DRAWN BY	K.R.	APPROVED BY	C.L.D.
HOR. SCALE:	AS. NOTED	RELEASED FOR CONSTRUCTION:	
VERTICAL:		DATE	2015.11.05

ENGINEER'S SEAL
CONSULTANT DRAWING NO. **G-105**

THE CITY OF WINNIPEG
PLANNING, PROPERTY & DEVELOPMENT
Winnipeg
ST. BONIFACE INDUSTRIAL PARK - PHASE 2
WASTEWATER PUMPING STATION
SITE PLAN AND DETAILS

SHEET **I** OF **I**
CAD FILE DRAWING NUMBER **09351c-105-846.DWG**
CITY DRAWING NUMBER **I-0215L-60101-001**

WARNING
IF POWER EQUIPMENT OR EXPLOSIVES ARE TO BE USED FOR EXCAVATION ON THIS PROJECT THE CONTRACTOR MUST:
1) NOTIFY THE GAS COMPANY OF THE PROPOSED LOCATION OF EXCAVATION.
2) TAKE PRECAUTION TO AVOID DAMAGE TO GAS COMPANY INSTALLATIONS.
SEE PROVINCIAL REGULATION 140/92 FOR DETAILS

METRIC
WHOLE NUMBERS INDICATE MILLIMETRES
DECIMALIZED NUMBERS INDICATE METRES

APEGM
Certificate of Authorization
Stantec Consulting Ltd.
No. 1301