
Location: CONTROL ROOM RM-M-121 Supply From: XFMR-U70E Mounting: MCC BUILT-IN Enclosure: Type 1

Volts: 120/208 Wye Phases: 3

Wires: 4

A.I.C. Rating: Mains Type: Mains Rating: 225 A MCB Rating: 225 A

СКТ	Circuit Description	Trip	Poles	A	В	С	Poles	Trip	Circuit Description	СКТ
1	EXTERIOR RECEPTACLE	15 A	1				1	15 A	EXTERIOR LIGHTING	2
3	GENERATOR ROOM RECEPTACLES	15 A	1				1	15 A	CONTROL ROOM LIGHTING, EXIT & EMERG.	4
5	CONTROL ROOM RECEPTACLES	15 A	1				1	15 A	GENERATOR ROOM LIGHTING, EXIT & EMERG.	6
7	CHAMBER LIGHTING	15 A	1				1	15 A	GENERATOR BATTERY CHARGER	8
9	GENERATOR BLOCK HEATER	40 A	2				1	15 A	MAIN PLC CABINET	10
11							1	15 A	CONTROL PANEL	12
13	HEAT TRACE GFCI	15 A	2				1	15 A	ULTRASONIC LEVEL	14
15							1	15 A	SF-U-21 SUPPLY FAN GENERATOR ROOM	16
17	RECEPTACLE FOR MTS SERVICE	15 A	1							18
19										20
21										22
23										24
25										26
27										28
29										30
31										32
33										34
35										36
37										38
39	BRIDGE LIGHTING NOTE 1	15 A	1							40
41	BRIDGE LIGHTING NOTE 1	15 A	1							42
NOTES: 1. REFER TO DILLION CONSULTING DRAWINGS C2-CS-062 AND C2-CS-063.										

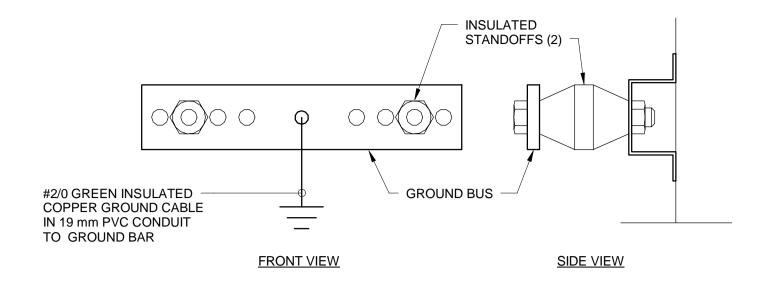


NOTES:

- NEW COPPER GROUND BAR (1000x100x6 EACH ELECTRICAL ROOM) WITH HOLES PREPUNCHED FOR
- DOUBLE BOLT CONNECTORS AND INSULATED STANDOFFS. CONNECT NEW #2/0 GROUND CABLE.
- GROUND CONNECTORS TO BE TAGGED ON BOTH ENDS IDENTIFYING LOCATION AND DEVICE.
- GROUND CABLE TO BE INSTALLED ON SUPPORTS WHERE POSSIBLE. PROVIDE SUPPORTS WHERE NEEDED.

2 GROUNDING BAR DETAIL

BE-006 SCALE: N.T.S.

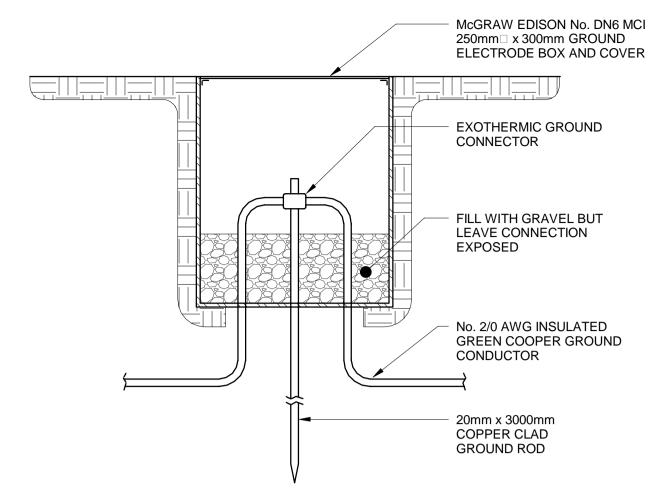


3 GROUND WELL DETAIL


BE-006 SCALE: N.T.S.

	LUMINAIRE SCHEDULE							
SYMBOL	SYMBOL LABEL TYPE VOLTS LAMP		LAMP	DESCRIPTION	MANUFACTORER CATALOG NUMBER	MOUNTING		
	A	LED	120V		LONG LIFE LED FIXTURE WITH FIBERGLASS GASKETED HOUSING. MINIMUM 50000 HOURS, CUL LISTED.	METALUX: 4VT2-LD4-6-DR-UNV-L835-U COMPLETE SET WITH INSTALLATION KIT VT2-CHAIN/SET U ORACLE LIGHTING: 4-OW1IP-LED-6000L-DIM10-120-85- SSL-GSS	SURFACE MOUNTING	
	В	LED	120V		SUITABLE FOR CLASS 1 ZONE 1 AND CATEGORY 1 ENVIRONMENT, cUL LISTED OR CSA CERTIFIED.	RIG-A-LITE: SXPJ10LUGGW1 EMERSON: CMLED-W-25-3-D-5-BU-G	WALL MOUNTING	
	С	LED	120V	100W	INCLUDE VANDAL RESISTANCE PACKAGE AND PHOTOCELL	KEENE: SS3LED32704KUNVPCBP	WALL MOUNTING	
EXIT	D	LED	120 TO 347V AC, 12V DC	6W MR16	CSA 22.2 No. 141-10 CERTIFIED PICTOGRAM EXIT SIGN WITH SOLID METAL CONSTRUCTION, ILLUMINATED BY LONG-LIFE WHITE LED AND TWIN EMERGENCY LED EMERGENCY LIGHTS, UNIVERSAL AC INPUT: TWO-WIRE 120 TO 347VAC, MAINTENANCE-FREE LEAD-CALCIUM BATTERY.	EMERGI-LITE: EAC1W12502LGUN	UNIVERSAL MOUNTING	
	D1	LED	12VDC	6W MR16	CSA 22.2 No. 250 CERTIFIED REMOTE FIXTURES, WHITE COLOUR, MR16 LED LAMPS, WIRE TO D FIXTURE.	EMERGI-LITE: EF9DLG	WALL MOUNTING	

HEATER SCHEDULE						
TAG	LOCATION	MANUFACTURER	MODEL	HEATING CAPACITY, kW	VOLTS/Ph/Hz	THERMOSTAT
UH-U70E-01	CONTROL ROOM RM-M-121	CALORITECH	GE-05-8-T	5	600/3/60	INTEGRAL
UH-U70-02	GENERATOR ROOM RM-M-122	CALORITECH	GE-05-8-T	5	600/3/60	INTEGRAL
UH-U70-03	INTERMEDIATE LEVEL	RUFFNECK	FX5-600360-100-T	10	600/3/60	INTEGRAL
UH-U70-04	INTERMEDIATE LEVEL	RUFFNECK	FX5-600360-100-T	10	600/3/60	INTEGRAL

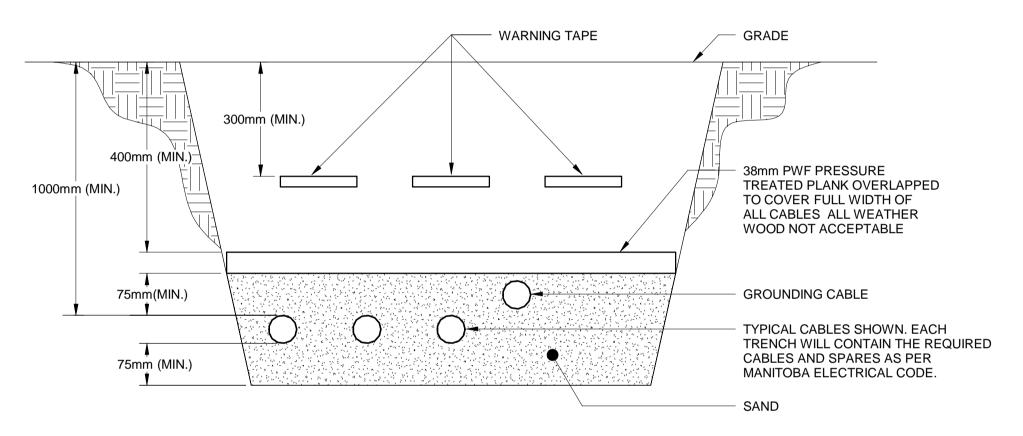

4 DIRECT BURIED TRENCH SCALE: N.T.S. BE-006

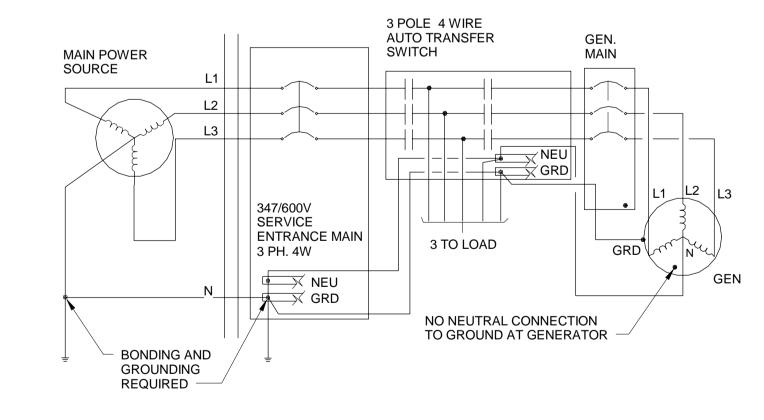

STANDBY GENERATOR 5 GROUNDING


SCALE: N.T.S.

BE-006



METRIC WHOLE NUMBERS INDICATE MILLIMETRES DECIMALIZED NUMBERS INDICATE METRES

NDERGROUND STRUCTURES	B.M ELE					Λ <i>=(</i>	COM	I	ENGINE
PV. U/G STRUCTURES DATE					_	AS			4 Q
					DESIGNED BY	RB	CHECKED BY	LCS	REGIS
CATION OF UNDERGROUND STRUCTURES AS OWN ARE BASED ON THE BEST INFORMATION					DRAWN BY	RC	APPROVED BY	SS	- ISTER
AILABLE. BUT NO GUARANTEE IS GIVEN AT ALL EXISTING UTILITIES ARE SHOWN OR AT THE GIVEN LOCATIONS ARE EXACT. DIVIFIRMATION OF EXISTENCE AND EXACT CATION OF ALL SERVICES MUST BE	1	ADDENDUM #5 ISSUED FOR TENDER	17/03/01 17/01/09	RC RC	HOR. SCALE VERTICAL	AS SHOWN	RELEASED FOR CONSTRUCTION		CONSU
STAINED FROM THE INDIVIDUAL UTILITIES (FORE PROCEEDING WITH CONSTRUCTION).	NO.	REVISIONS	DATE	BY	DATE	06/01/2016	DATE	05/30/16	

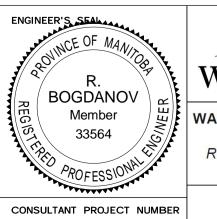

Winnipeg
WAVERLEY STRE

THE CITY OF WINNIPEG PUBLIC WORKS DEPARTMENT

REET UNDERPASS AT CN MILE 3.89 RIVERS SUB CONTRACT 2: UNDERPASS STRUCTURE, RAILWORKS, ROADWORKS, LAND DRAINAGE SEWER, PUMPING STATION

AND LANDSCAPING WORKS CONSULTANT DRAWING NUMBER PUMPING STATION

60321148

SCHEDULES AND DETAILS

C2-BE-006

U-239-2016-C2-BE-006