

THE CITY OF WINNIPEG PLANNING, PROPERTY AND DEVELOPMENT DEPARTMENT MUNICIPAL ACCOMMODATIONS DIVISION 4TH FLOOR - 185 KING STREET R3B 1J1

Project: St. Vital Library

6 Fermor Ave. Winnipeg Manitoba

Project Number: 16054 Bid Opportunity Number: 768-2016

Drawing Title:

NEW MAIN FLOOR LIGHTING
PLAN

Issue/Revision Date

ISSUED FOR CONSTRUCTION ADDENDUM #1 OCT 31, 2016

APEGIN


Certificate of Authorization

HDK Consulting Incorporated

No. 5539 Date: 04/30/2017

Sheet No: E-9

This drawing is property of the Architect and cannot be reproduced or used without the consent of the Architect. The contractor is responsible for checking and verifying all levels and dimensions and shall report all discrepancies to the Architect and obtain clarification prior to commencing work.

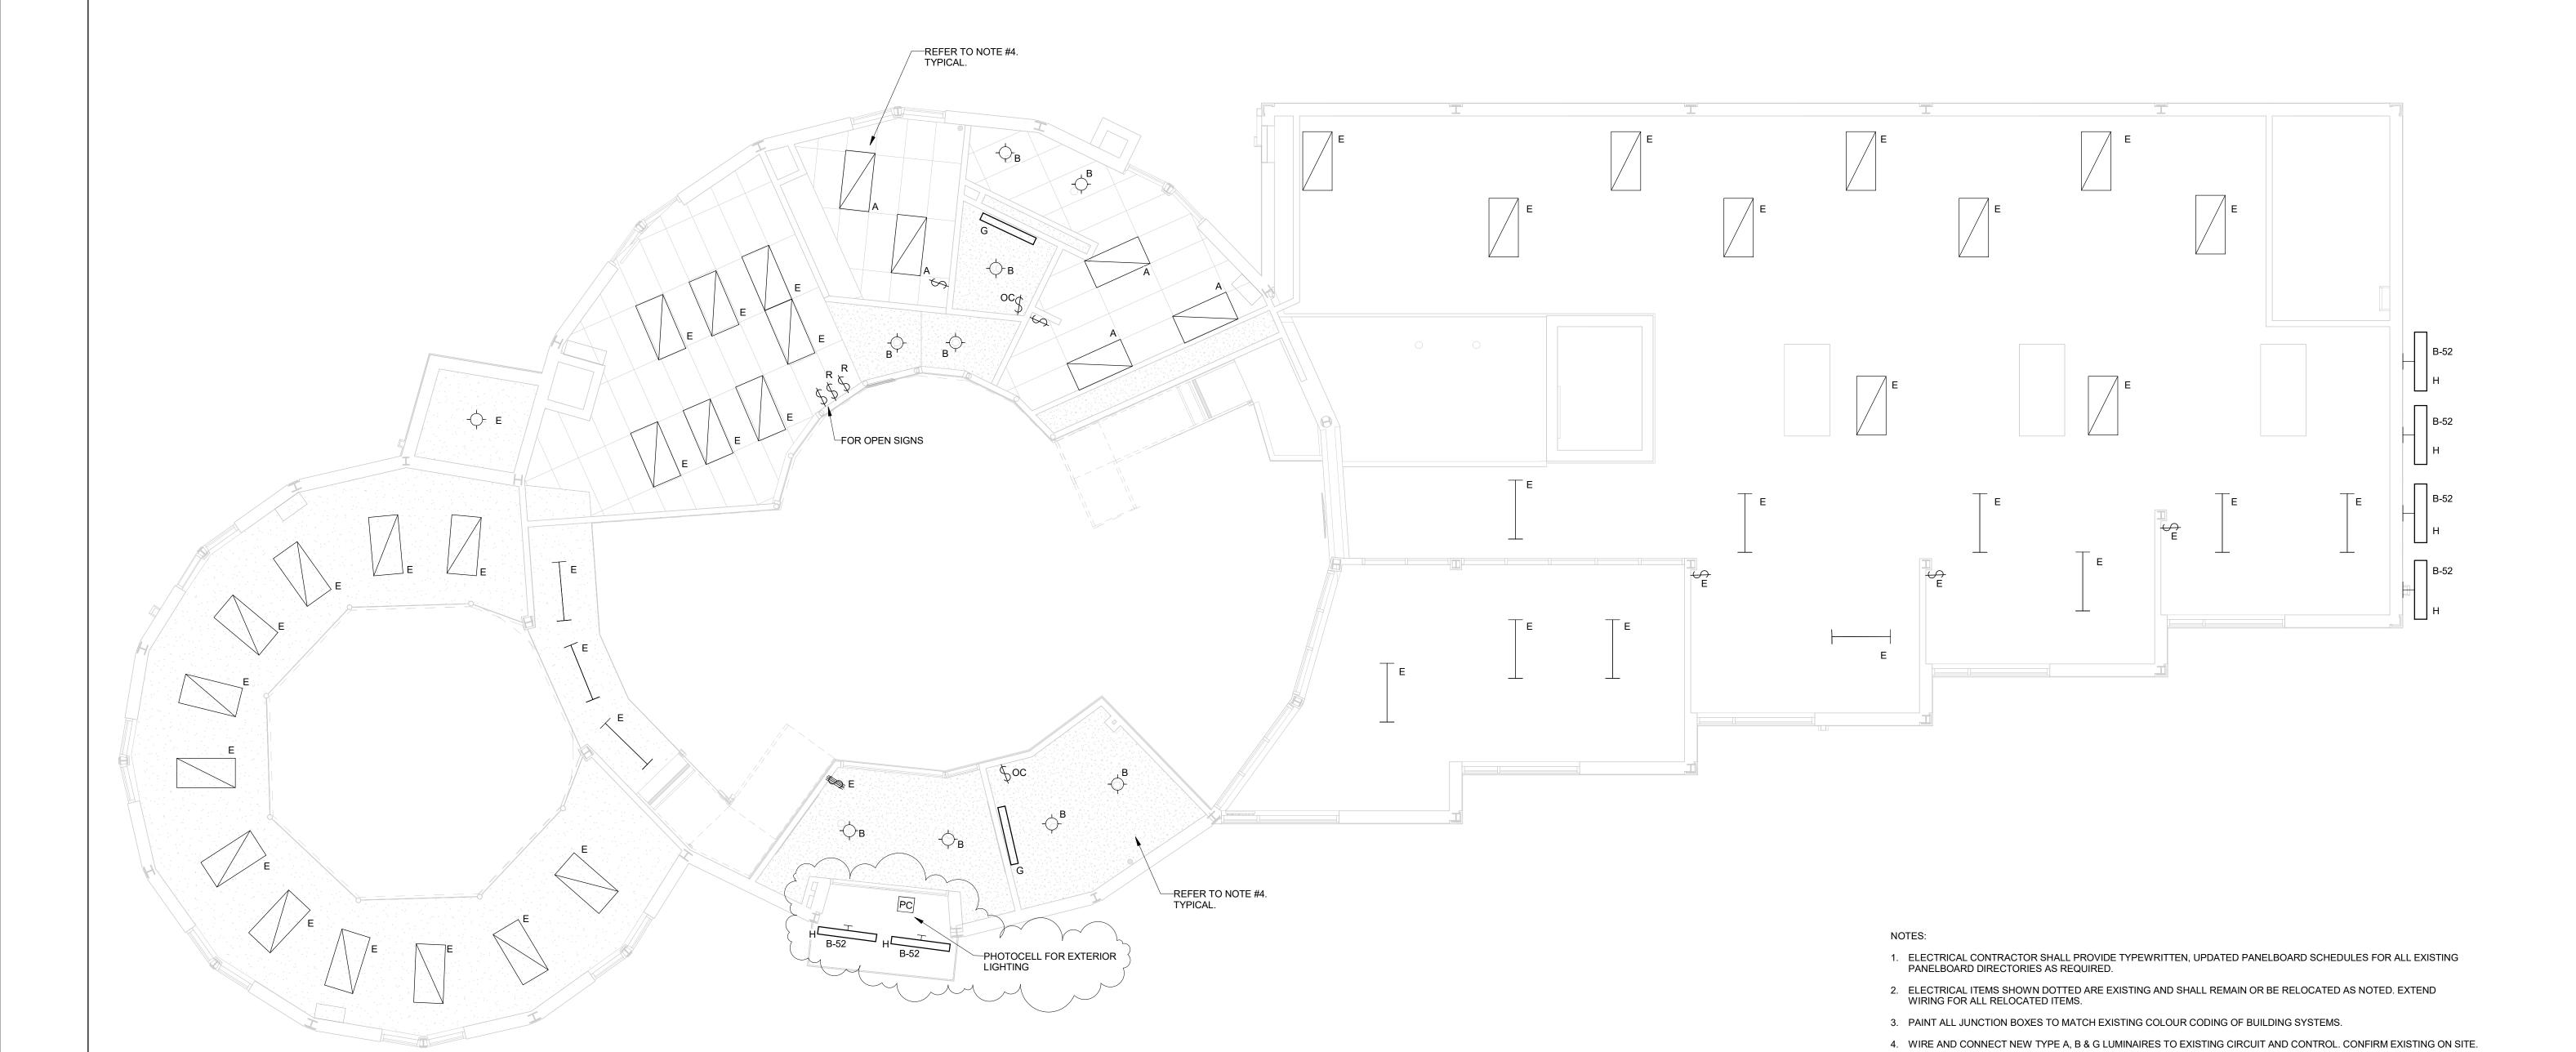

NEW MAIN FLOOR LIGHTING PLAN
3/16" = 1'-0"