
# DYNASTY BUILDING

## COURTYARD WATERPROOFING

WINNIPEG, MANITOBA 180 KING STREET

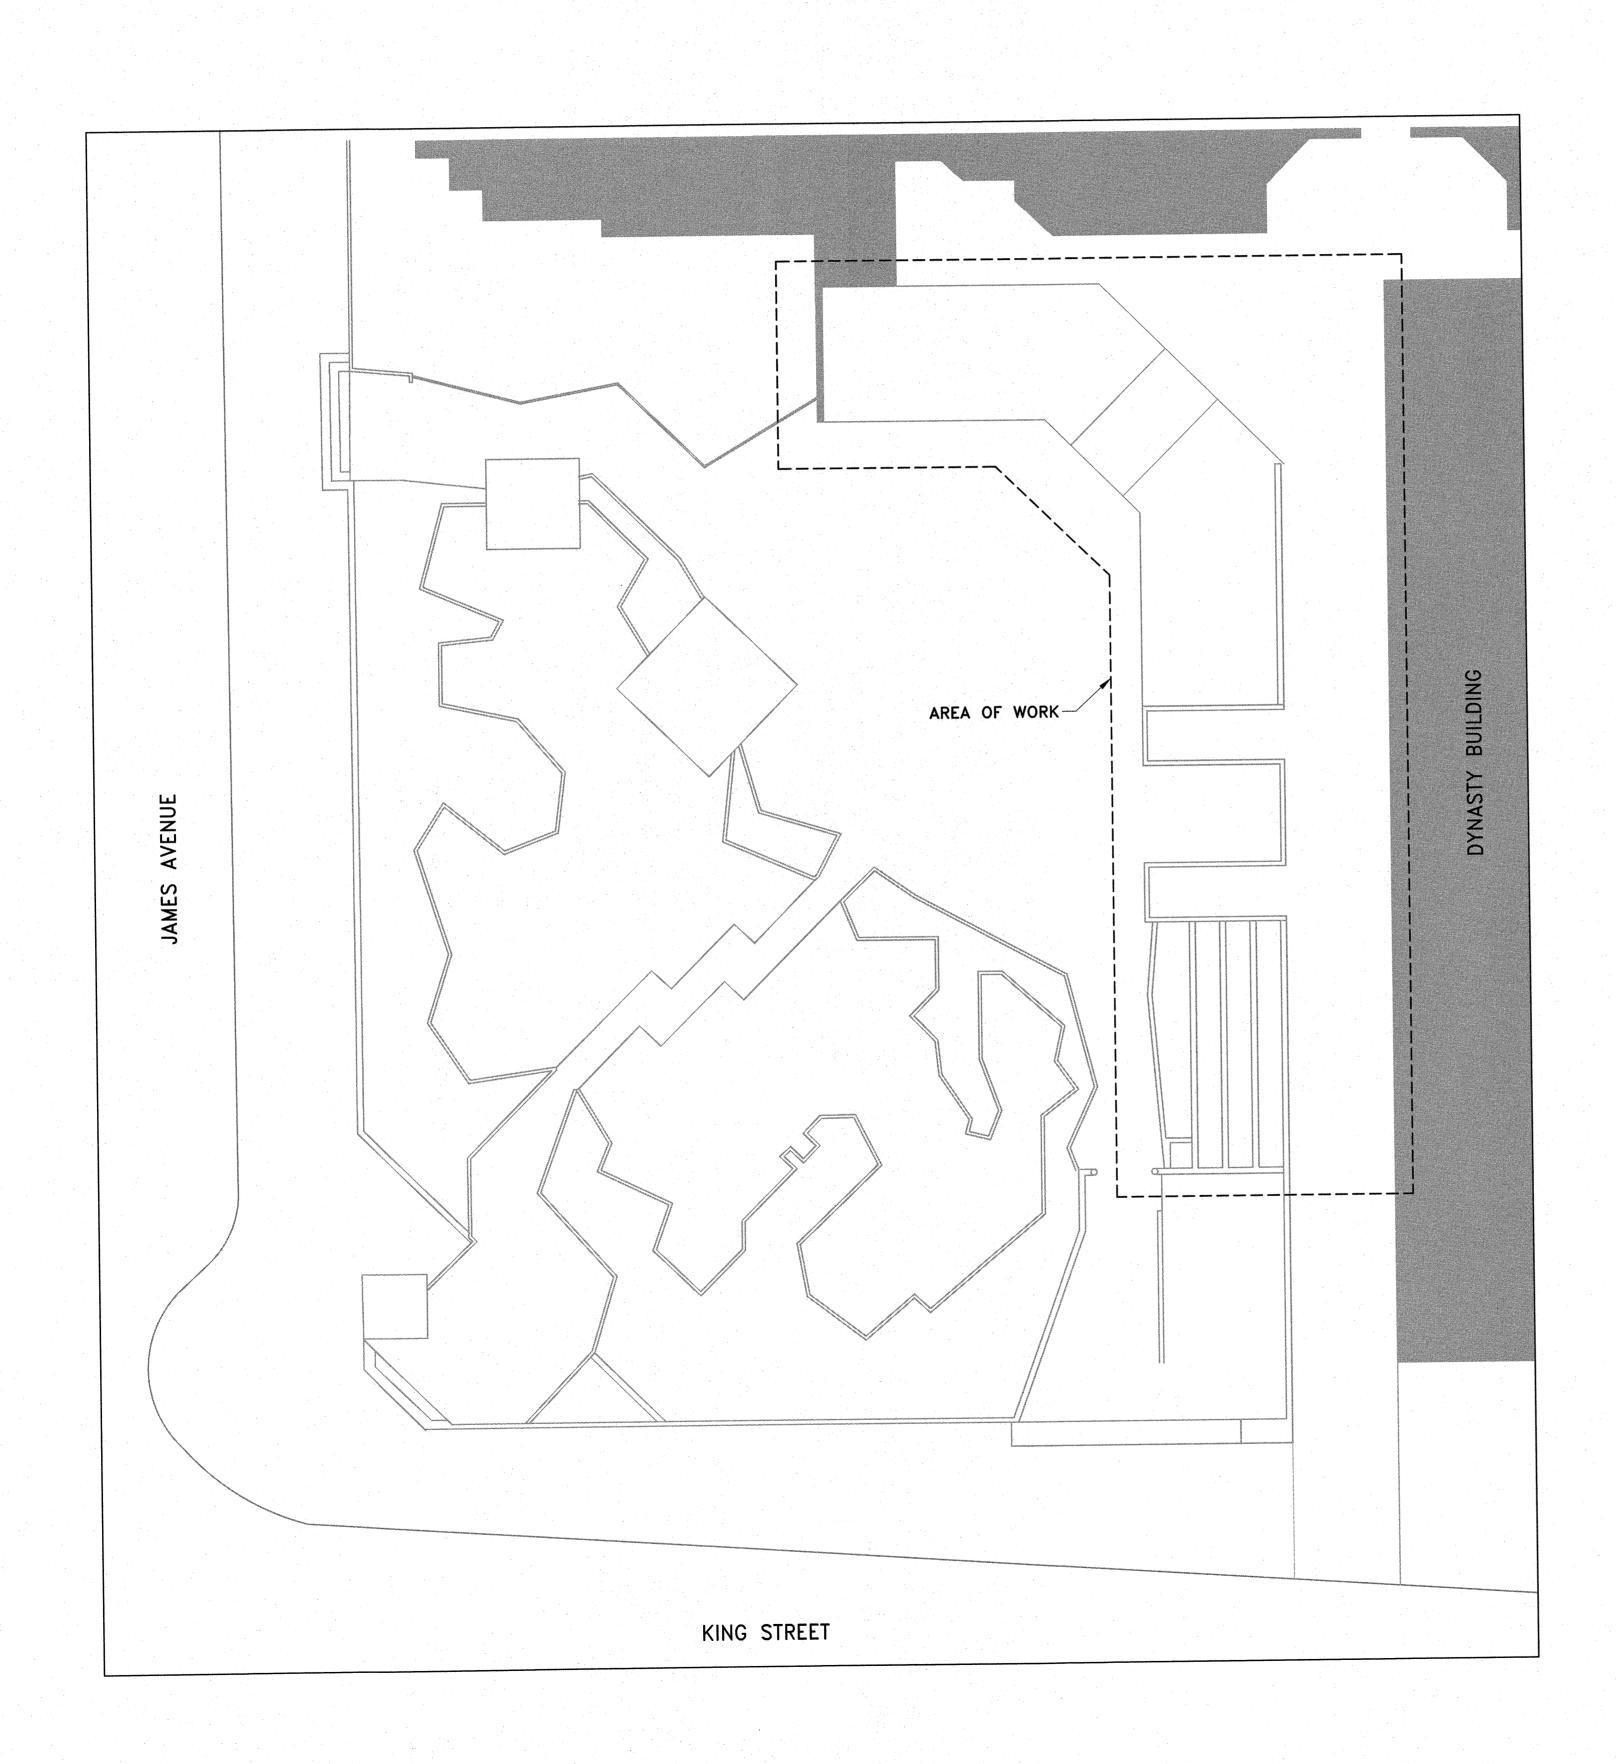

#### PRIME CONSULTANT:

300-275 Carlton Street Winnipeg, Manitoba R3C 5R6 T 204. 943. 7501 F 204. 943. 7507 2017-0306




Crosier Kilgour & Partners Ltd. CONSULTING STRUCTURAL ENGINEERS


#### **DRAWING INDEX:**

- SO.1 SITE PLAN, GENERAL NOTES & DRAWING INDEX S2.1 COURTYARD FLOOR PLAN S4.1 SECTIONS S5.1 DETAILS S6.1 TYPICAL CONCRETE REPAIR DETAILS S6.2 TYPICAL WATERPROOFING MEMBRANE DETAILS

### **GENERAL NOTES:**

- DO NOT SCALE DRAWINGS.
  ALL DIMENSIONS ARE TO BE VERIFIED ON—SITE PRIOR TO
- 3. COORDINATE WORK NEAR MECHANICAL AND ELECTRICAL SERVICES WITH
- SITE PERSONNEL. 4. ACTUAL ON-SITE CONDITIONS MAY VARY FROM THAT SHOWN; INFORMATION SHOWN OBTAINED FROM ORIGINAL DRAWINGS. ONUS REMAINS WITH CONTRACTOR TO VERIFY ALL ON-SITE CONDITIONS AND REPORT ANY DISCREPANCIES TO CONTRACT ADMINISTRATOR.
- 5. BARRICADE ALL WORK AREAS FROM PUBLIC ACCESS. PROTECT ALL AREAS DURING PERIODS WHEN OFF-SITE.
- 6. UNIT PRICE REPAIRS LOCATIONS SHOWN ON DRAWINGS ARE FOR INFORMATION PURPOSES ONLY. LOCATIONS AND EXTENTS TO BE SITE
- 7. THESE STRUCTURAL DRAWINGS SHOW THE COMPLETED STRUCTURE AND DO NOT INDICATE ALL COMPONENTS NECESSARY FOR SAFETY DURING CONSTRUCTION. THE CONTRACTOR SHALL BE SOLELY RESPONSIBLE FOR SAFETY ON AND AROUND THE JOBSITE DURING CONSTRUCTION.
- 8. CONTRACTOR TO MAINTAIN SAFE EXIT FROM BUILDING IN CASE OF EMERGENCY.

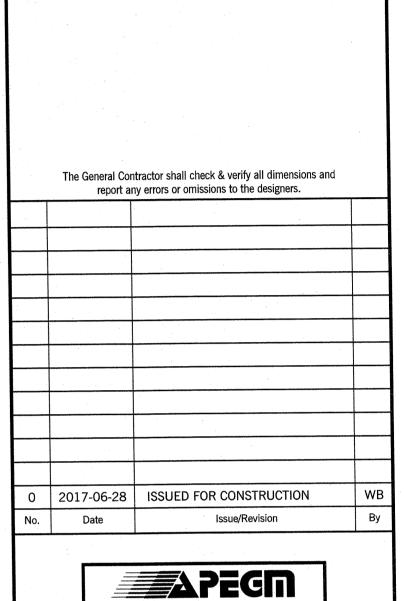

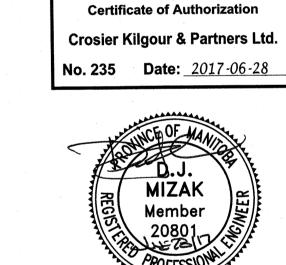

Consultant

Winnipeg, Manitoba R3C 5R6 T 204. 943. 7501 F 204. 943. 7507

Crosier Kilgour CONSULTING STRUCTURAL ENGINEERS

DYNASTY BUILDING

COURTYARD WATERPROOFING 180 KING STREET

WINNIPEG, MANITOBA

SITE PLAN, GENERAL NOTES, DRAWING INDEX 2017-06-28 2017-0306

Sheet No.

RJM