


END SECTION DETAIL SCALE: N.T.S.

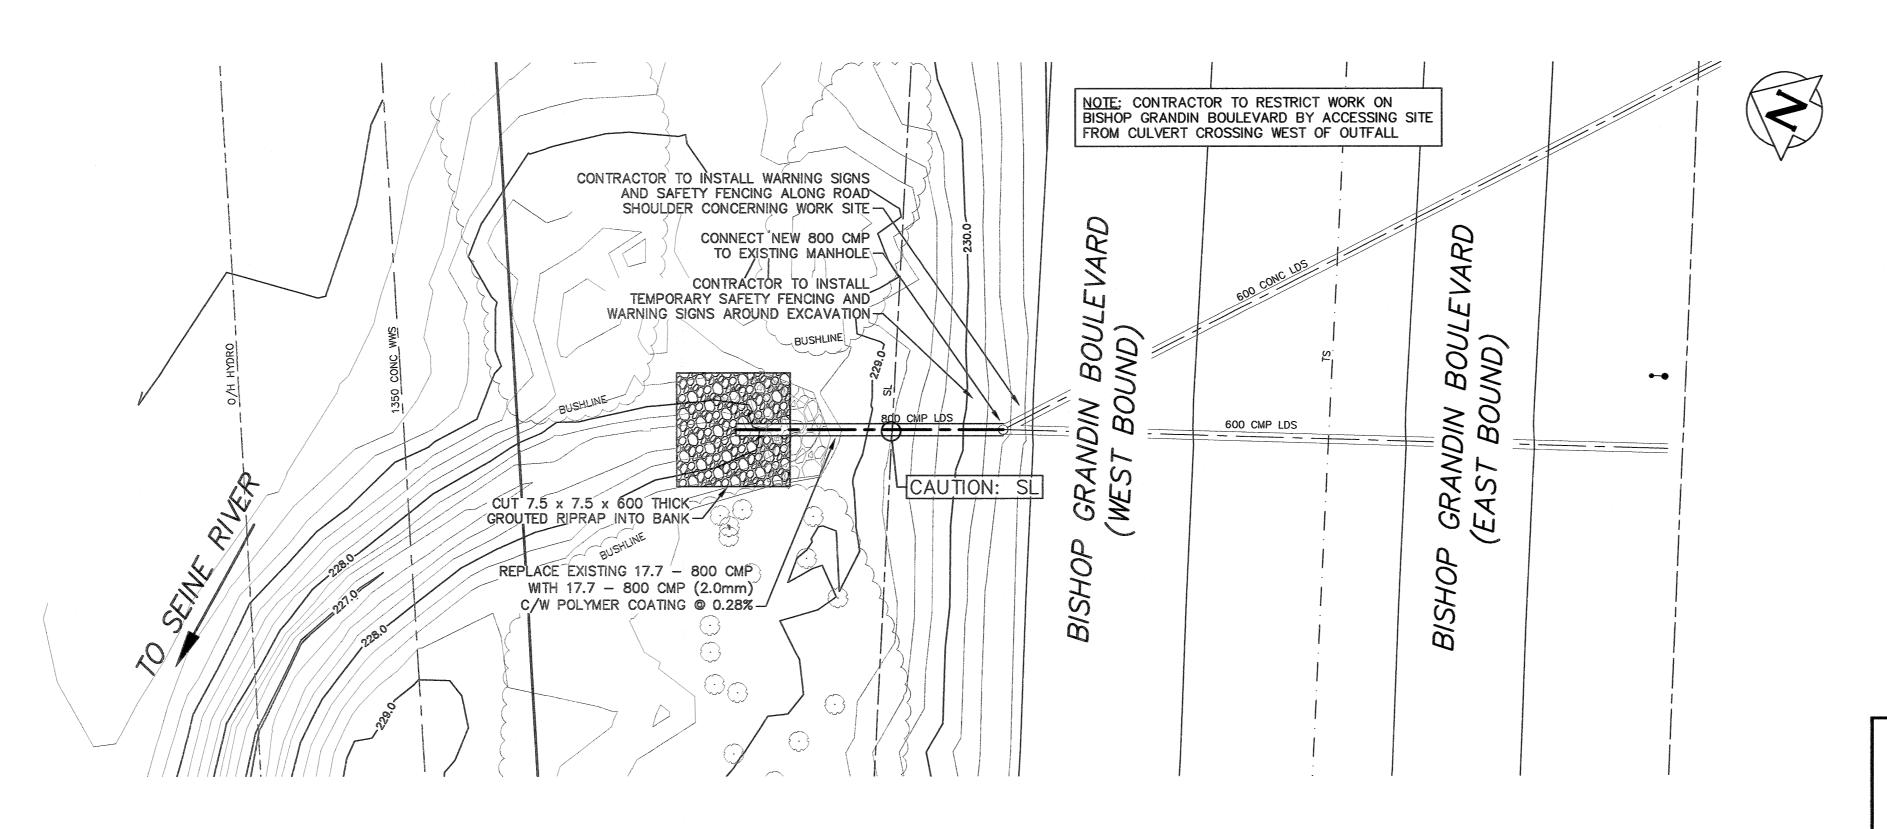

NOTES:

- 1. ALL EXCAVATED MATERIAL WITHIN 107.0 OF THE REGULATED SUMMER RIVER LEVEL (RSRL) MUST BE REMOVED FROM SITE (NO STOCK PILING).
- 2. REMOVE AND REPLACE TREES AS DIRECTED BY CONTRACT ADMINISTRATOR.
- 3. CONTRACTOR TO EXPOSE ALL UTILITIES BEING CROSSED PRIOR TO EXCAVATING.
- 4. CONTRACTOR TO INSTALL TEMPORARY SAFETY FENCING AROUND EXCAVATION.
- 5. CMP TO MANHOLE CONNECTION TO BE 150 REINFORCED CONCRETE COLLAR IN CONJUNCTION WITH WATER-STOP GROUT RING.

PROPERTY LIMITS DELINEATION

DELINEATION OF PROPERTY LIMITS AS SHOWN ON THIS DWG DOES NOT REPRESENT A "LEGAL SURVEY". KGS GROUP MAKES NO REPRESENTATION OR WARRANTY AS TO THE ACCURACY OF PROPERTY LIMITS DELINEATED ON THIS DWG, NOR ON THE DIMENSIONAL ACCURACY OF DWG FEATURES RELATIVE TO THOSE PROPERTY LIMITS.

WARNING

TO GAS COMPANY INSTALLATIONS.

SEE PROVINCIAL REGULATION 210/72 FOR DETAILS

IF POWER EQUIPMENT OR EXPLOSIVES ARE TO BE USED FOR EXCAVATION ON THIS PROJECT THE CONTRACTOR MUST:

1) NOTIFY THE GAS COMPANY OF THE PROPOSED LOCATION OF EXCAVATION. 2) TAKE PRECAUTION TO AVOID DAMAGE SUPV. U/G STRUCTURES COMMITTEE DATE NOTE: LOCATION OF UNDERGROUND STRUCTURES AS SHOWN ARE BASED ON THE BEST INFORMATION AVAILABLE BUT NO GUARANTEE IS GIVEN THAT ALL EXISTING UTILITIES ARE SHOWN OR THAT THE GIVEN LOCATIONS ARE EXACT. CONFIRMATION OF EXISTENCE AND EXACT LOCATION OF ALL SERVICES MUST BE OBTAINED FROM THE INDIVIDUAL UTILITIES BEFORE PROCEEDING WITH CONSTRUCTION.

LOCATION APPROVED

UNDERGROUND STRUCTURES

KGS ELEV. GROUP CONSULTING ENGINEERS CHECKED RBO DESIGNED APPROVED RBO GEL

ISSUED FOR TENDER

OFFMAN

ENGINEERS GEOSCIENTISTS

Certificate of Authorization

KGS Group

No. 245

ENGINEER'S SEAL

MANITOBA

Winnipeg

THE CITY OF WINNIPEG WATER AND WASTE DEPARTMENT ENGINEERING DIVISION

2019 OUTFALL RENEWAL REHABILITATION PROGRAM

SHEET 13 OF 16 CITY DRAWING NUMBER

LD-8869

BISHOP GRANDIN BOULEVARD OUTFALL PLAN AND PROFILE

S-MA70015994

DECIMALIZED NUMBERS INDICATE METRES

METRIC

WHOLE NUMBERS INDICATE MILLIMETRES

RELEASED FOR CONSTRUCTION SCALE: HORIZONTAL 1:250 1:50 VERTICAL 2018 11 21 830 DATE / 12/20/19 DATE BY DATE 2018 11 20 2018 11 20

BID OPPORTUNITY: 1042-2018 CONTRACT NUMBER:

CONSULTANT DRAWING NUMBER

18-0107-013_LD-8869

FILE PATH: P:\Projects\2018\18-0107-013\Dwg\Mun\ FILE NAME: 18-0107-013_PP.dwg