



PLAN AT PUMP FLOOR  
1:50

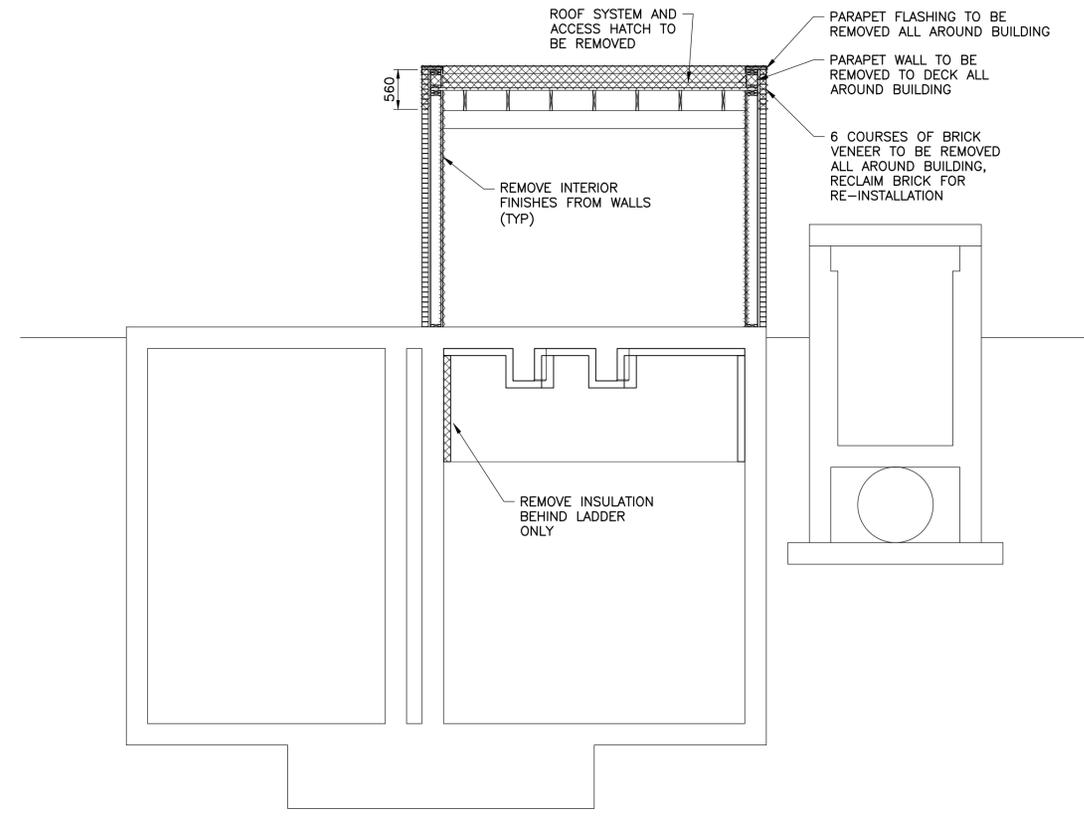

SECTION  
1:50

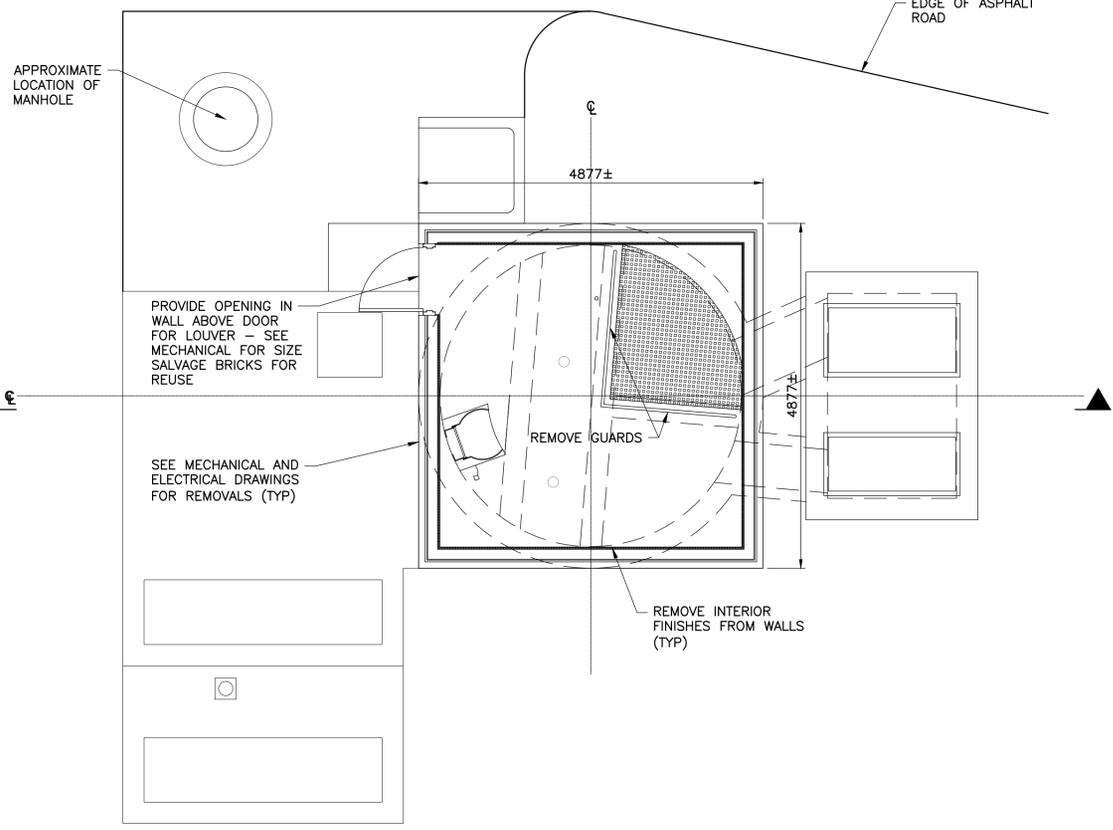

PLAN AT MOTOR FLOOR  
1:50

- GENERAL NOTES:
1. THE CONTRACTOR SHALL BE RESPONSIBLE FOR SITE PREPARATION.
  2. ALL DIMENSIONS, DETAILS, ELEVATIONS AND CONDITIONS SHOWN ON DRAWINGS ARE DERIVED FROM AVAILABLE INFORMATION AND SITE OBSERVATION AND SHALL BE VERIFIED BY THE CONTRACTOR PRIOR TO COMMENCING WITH CONSTRUCTION WORK. ANY DISCREPANCY OR CONFLICT SHALL BE REPORTED TO THE CONSULTANT.
  3. CONTRACTOR MUST SAFEGUARD AND PROTECT ALL EXISTING UTILITIES DURING THE CONSTRUCTION. ANY DAMAGE TO EXISTING STRUCTURES AND UTILITIES BY THE CONTRACTOR RESULTING FROM DEMOLITION AND CONTRACTOR OPERATIONS MUST BE REPAIRED BY THE CONTRACTOR AT THEIR OWN COST.
  4. DO NOT CONSTRUCT FROM THE DRAWINGS UNLESS MARKED "ISSUED FOR CONSTRUCTION".
  5. DO NOT SCALE FROM THE DRAWINGS.
  6. ALL WORK SHALL CONFORM TO THE LATEST MANITOBA BUILDING CODE AND THE ASSOCIATING NATIONAL BUILDING CODE OF CANADA.
  7. THE CONTRACTOR SHALL BE RESPONSIBLE FOR SITE SECURITY.
- EXCAVATION:
1. THE CONTRACTOR SHALL CONFIRM THE LOCATIONS OF EXISTING UTILITIES PRIOR TO EXCAVATING.
  2. TEMPORARY SUPPORT, BRACING, AND/OR SHORING FOR CONSTRUCTION, IF REQUIRED, IS THE RESPONSIBILITY OF THE CONTRACTOR.
  3. THE CONTRACTOR SHALL BE RESPONSIBLE TO RECONNECT THE EXISTING UTILITIES AND RESTORE SITE AT NO EXTRA COST.
- DESIGN LOADING - ROOF TRUSSES
1. ENGINEERED ROOF TRUSS AND THE CONNECTIONS TO BE DESIGNED FOR WIND LOAD:  $q_1/50 = 0.45$  KPA WITH IMPORTANT FACTOR:  $w = 1.25$ .

METRIC  
WHOLE NUMBERS INDICATE MILLIMETRES  
DECIMALIZED NUMBERS INDICATE METRES

FILENAME: C:\PROJECTS\WORKING DIRECTORY\PROJECTS 2018\4065\UNITS\661\186872\_01\_ARCH\_DESIGNING PLOTTED BY: GRAHN, OREG  
 PLOT DATE: 2018-06-18 10:14:00 AM  
 PLOT SCALE: 1:50  
 PLOT SHEET: 1 OF 7  
 PLOT TITLE: 186872\_01\_ARCH\_DESIGNING

B.M. ELEV.		DESIGNED BY JAA		ENGINEER'S SEAL		<b>THE CITY OF WINNIPEG</b> WATER AND WASTE DEPARTMENT			
		DRAWN BY PDR		RELEASED FOR CONSTRUCTION NOT FOR CONSTRUCTION		CONSULTANT PROJECT NUMBER 18-6872	SYNDICATE FLOOD PUMPING STATION UPGRADES		CITY DRAWING NUMBER 1-0189F-B0001-001
		CHECKED BY NR					SHEET 1 OF 7		
		APPROVED BY MH					DEMOLITION FLOOR PLANS, CROSS SECTION		CONSULTANT DRAWING NUMBER A1
		HOR. SCALE AS SHOWN							
1 ISSUED FOR TENDER		15/06/18	BLM	VERTICAL					
NO.	REVISIONS	DATE	BY	DATE					