




1 CENTRIFUGAL ROOF EXHAUST FAN (MECHANICAL)
SCALE: N.T.S.

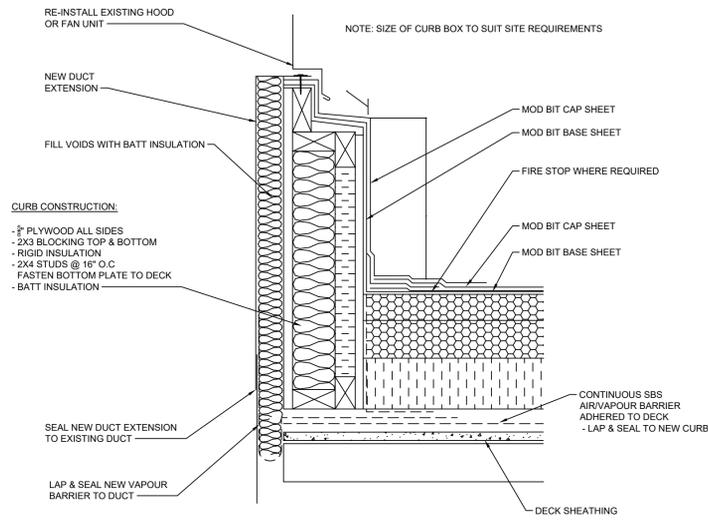


4 ROOF CURB @ EXHAUST DUCT DETAIL (MECHANICAL)
SCALE: N.T.S.

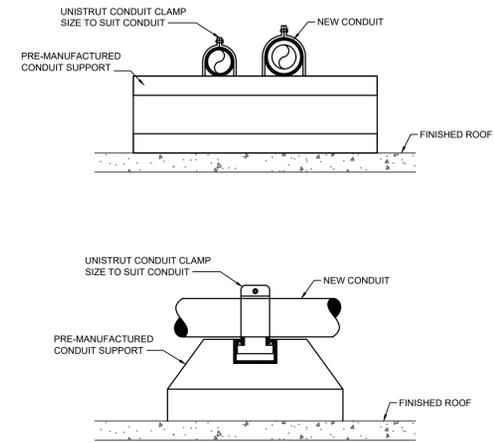


7 TYPICAL ROOF CONDUIT SUPPORT DETAIL (ELECTRICAL)
SCALE: N.T.S.

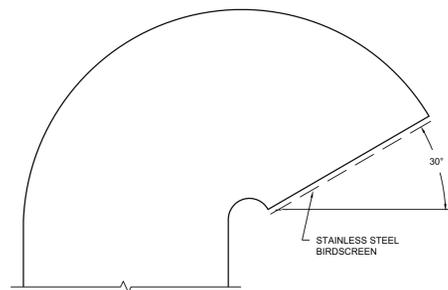


2 OUTLET GOOSENECK (MECHANICAL)
SCALE: N.T.S.

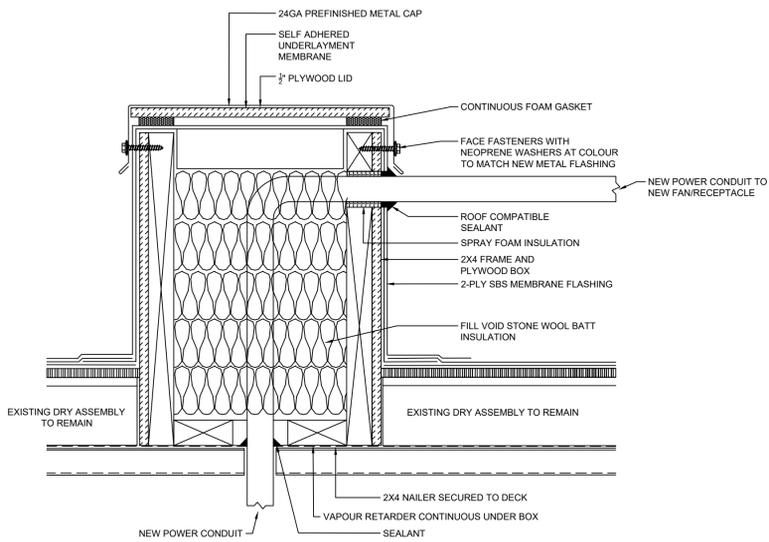

5 CONDUIT BOX DETAIL (ELECTRICAL)
SCALE: N.T.S.

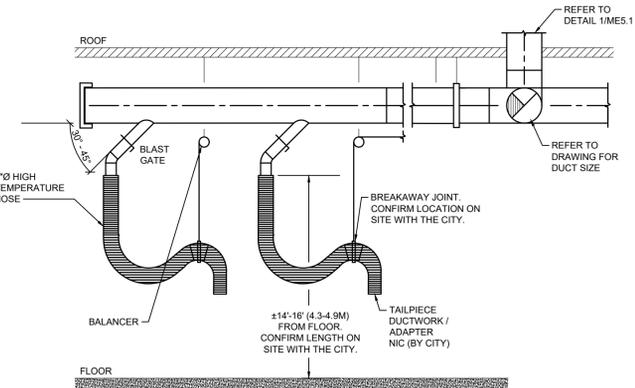


3 ABOVE FLOOR EXHAUST (MECHANICAL)
SCALE: N.T.S.

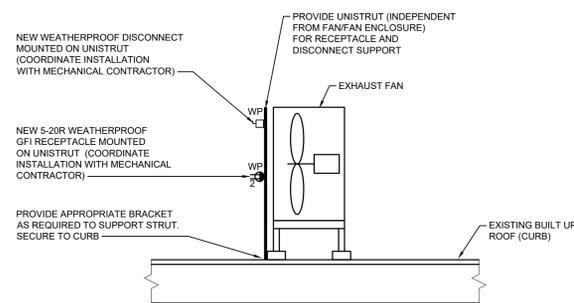

6 TYPICAL ROOF RECEPTACLE AND DISCONNECT MOUNTING DETAIL (ELECTRICAL)
SCALE: N.T.S.

NO.	Description	BY	DATE
0	ISSUED FOR CONSTRUCTION	JH/AS	09/07/21

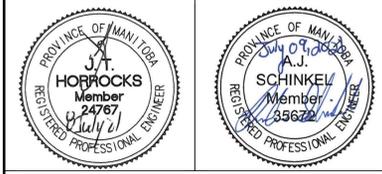

Project Title
TRANSIT HOIST 10-18 VEHICLE EXHAUST

WINNIPEG MANITOBA

Drawing Title
MECHANICAL AND ELECTRICAL DETAILS

Drawn By LP/WPD	Checked By XZ/CRM	Approved By JH/AS
Scale AS NOTED	Date JULY 2021	Project No. 21-083-01
Revision Number 0	Drawing Number ME5.1	Sheet Order 5 OF 5



FILE NAME AND PATH: G:\PROJECTS\2021\10-18 Transit Hoist 10-18 Vehicle Exhaust\3.0 Curb_Rev03.5_Mech2101011_ME5.1.dwg
 LAYOUT: ME5.1
 LAST SAVED BY: JH
 DATE PLOTTED: 2021-07-21 10:13 AM