
AST SAVE: 12/15/2022 11:18:57 AM ATH: BIM 360://City of Winnipeg - NEWPCC Upgrades 2021/60661262-ACM-F

A1 SI7F - 594mm x 841r

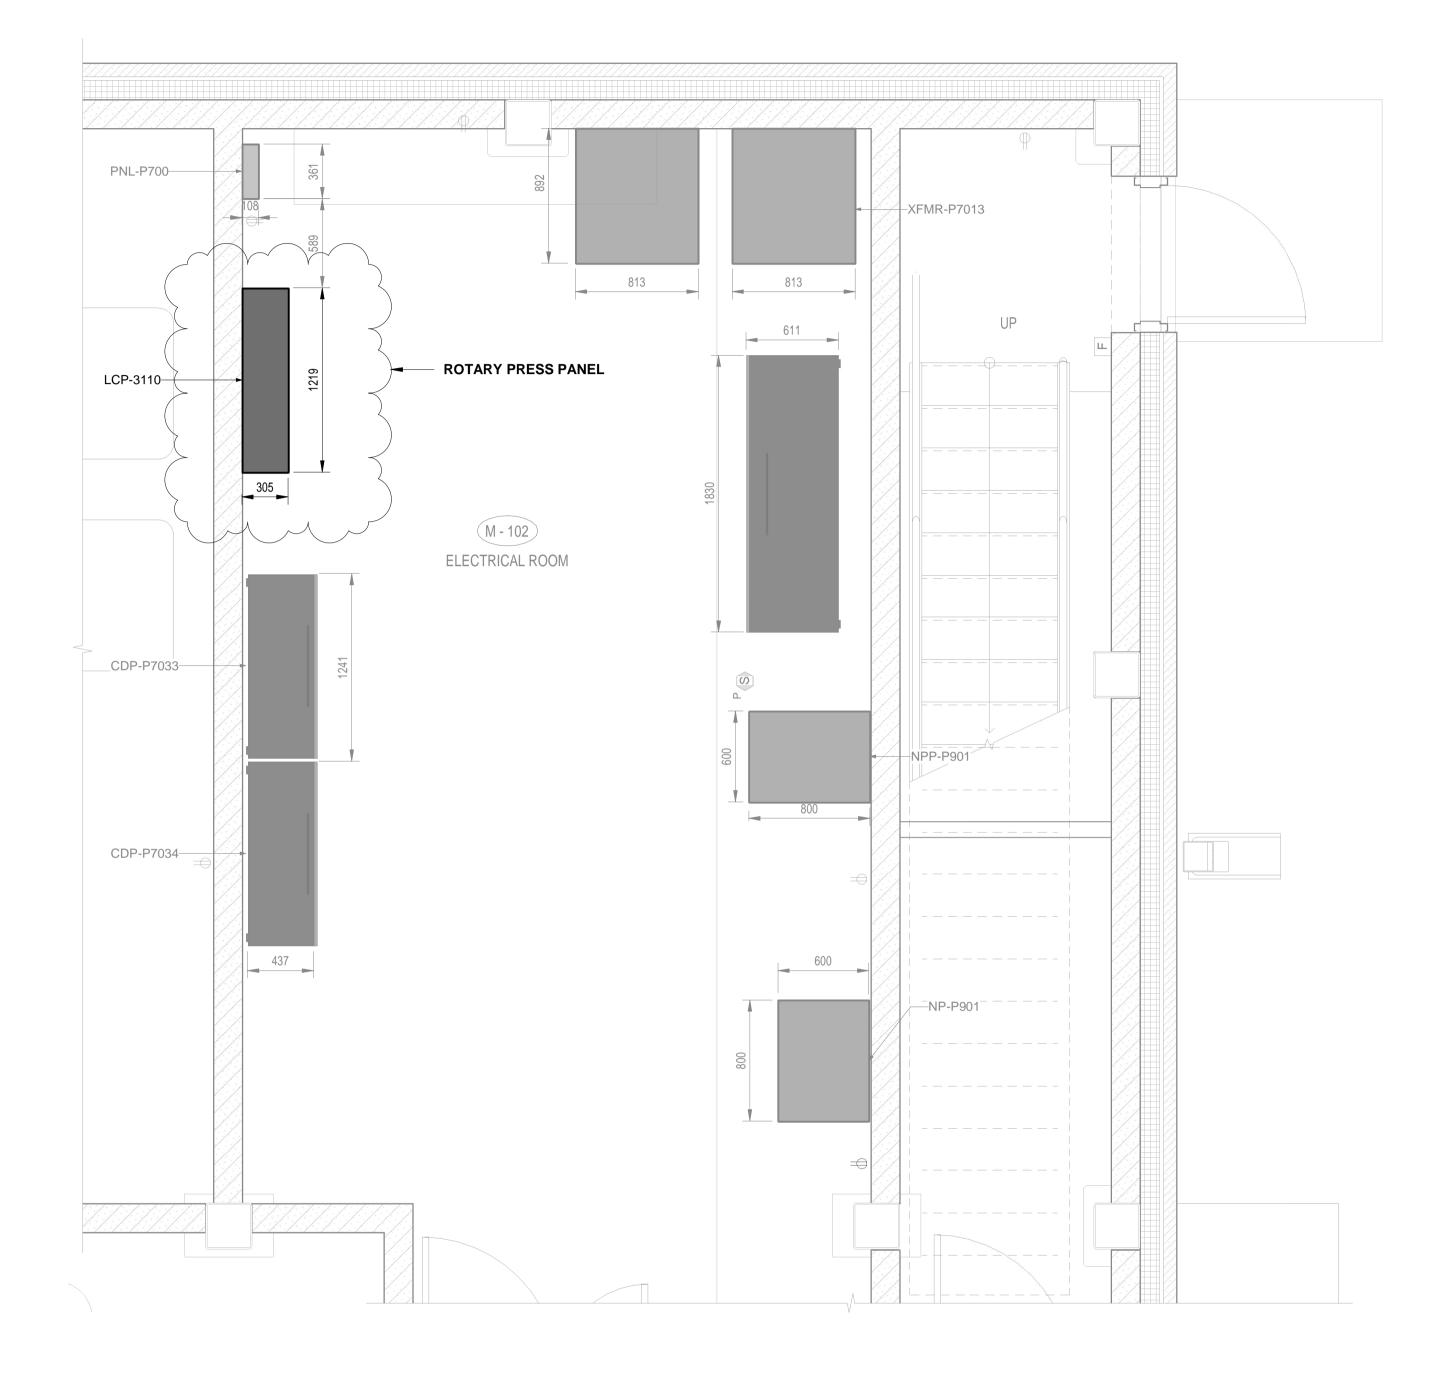

1	ENLARGE
	SCALE: 1:25

ED FLOOR PLAN - ELECTRICAL ROOM



