WINNIPEG TRANSIT - GARAGE BUILDING HOIST REPLACEMENT PROGRAM PHASE 3 - HOISTS 2-7

421 OSBORNE STREET, WINNIPEG, MANITOBA

PROJECT TEAM:

STRUCTURAL ENGINEERING CONSULTANT STANTEC CONSULTING LTD. 500-311 PORTAGE AVE. WINNIPEG, MANITOBA PH: (204) 489-5900

MECHANICAL ENGINEERING CONSULTANT STANTEC CONSULTING LTD. 500-311 PORTAGE AVE. WINNIPEG, MANITOBA PH: (204) 489-5900

ELECTRICAL ENGINEERING CONSULTANT STANTEC CONSULTING LTD. 500-311 PORTAGE AVE. WINNIPEG, MANITOBA

PH: (204) 489-5900

INDUSTRIAL ENGINEERING CONSULTANT STANTEC CONSULTING LTD. 1100-111 DUNSMUIR STREET. VANCOUVER, BC PH: (604) 696-8443

DRAWING INDEX:

GENERAL G-001 COVER SHEET

GENERAL NOTES DEMOLITION PLAN PILING PLAN

MAIN FLOOR FRAMING PLAN SECTIONS AND DETAILS SECTIONS AND DETAILS

 $\overline{M-101}$ MAIN FLOOR SANITARY DRAINAGE AND VENTILATION DEMOLITION PLAN M-102 MAIN FLOOR SANITARY DRAINAGE AND VENTILATION CONSTRUCTION PLAN

M-700 MECHANICAL SPECIFICATIONS

ELECTRICAL

E - 100MAIN FLOOR ELECTRICAL DEMOLITION PLAN NEW ELECTRICAL EQUIPMENT LAYOUT

ELECTRICAL PARTIAL SINGLE LINE DIAGRAM & MOTOR CONTROL DETAIL



AREA OF WORK

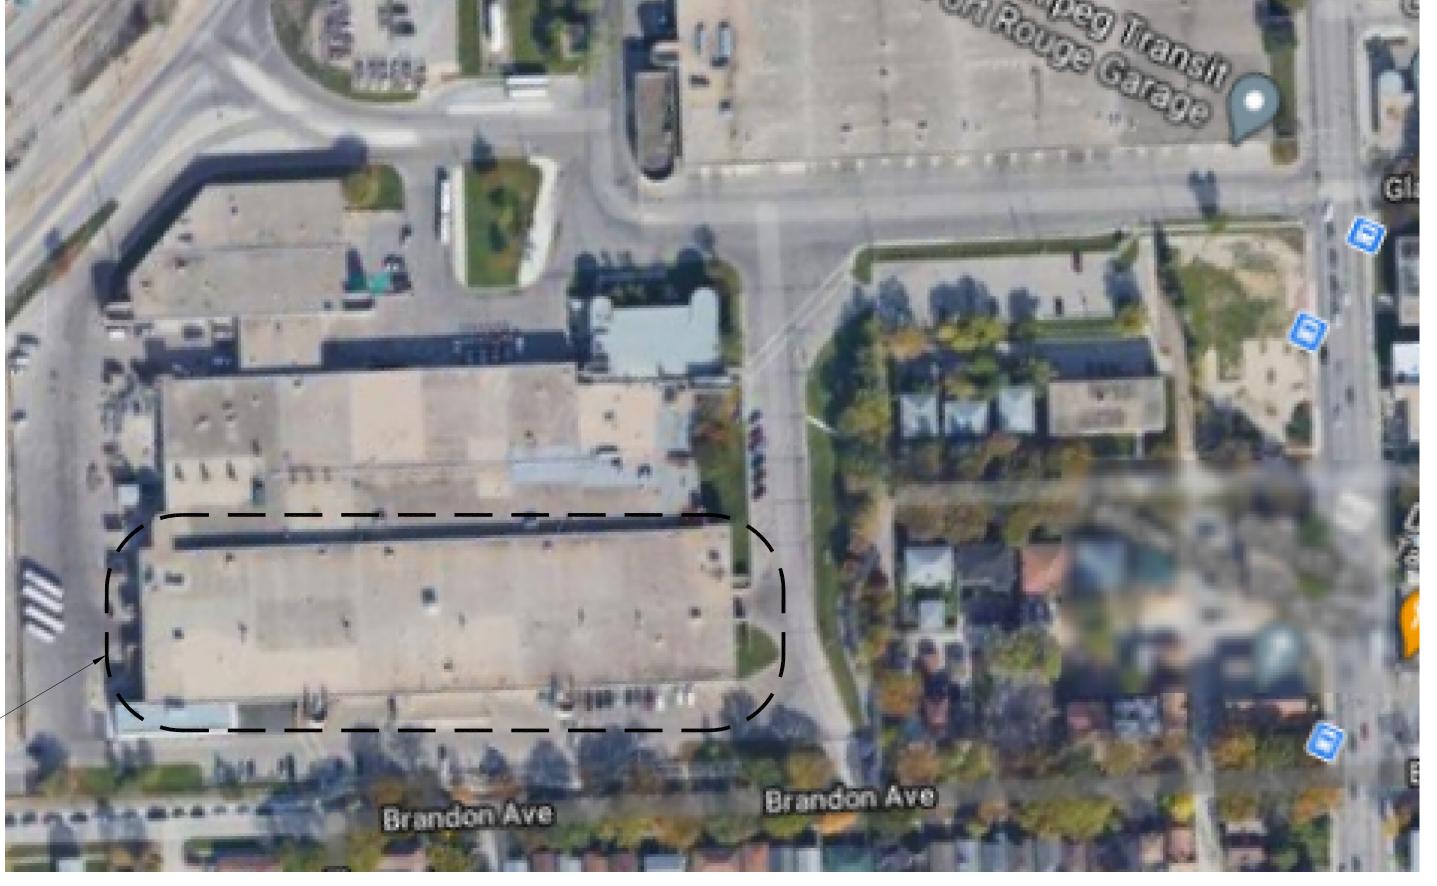


IMAGE COURTESY OF GOOGLE MAPS



Stantec Consulting Ltd. Suite 500, 311 Portage Avenue Winnipeg MB Canada R3B 2B9 Tel. 204.489.5900 Fax. 204.453.9012 www.stantec.com

Copyright Reserved

The Contractor shall verify and be responsible for all dimensions. DO NOT scale the drawing - any errors or omissions shall be reported The Copyrights to all designs and drawings are the property of Stantec. Reproduction or use for any purpose other than that authorized by

Consultants

Revision File Name: 22050_g-00

Permit-Seal





Client/Project WINNIPEG TRANSIT GARAGE BUILDING

HOIST REPLACEMENT PROGRAM PHASE 3 - HOISTS 2 - 7 421 Osborne Street, Winnipeg Manitoba

COVER SHEET

Project No. 115422050 Drawing No. Sheet Revision

DRIGINAL SHEET - ISO ARCH D - v17.05

880-2024 G-001 of