



NOTES:
 1. CONTRACTOR TO CONFIRM EXISTING PIT DIMENSIONS AND CONFIRM MINIMUM DIMENSIONS REQUIRED BY SUMP PUMP MANUFACTURER ARE MET.


11 SUMP PUMP P-L04 DISCHARGE PIPING DETAIL
 REF.2,3 SCALE: 1:15

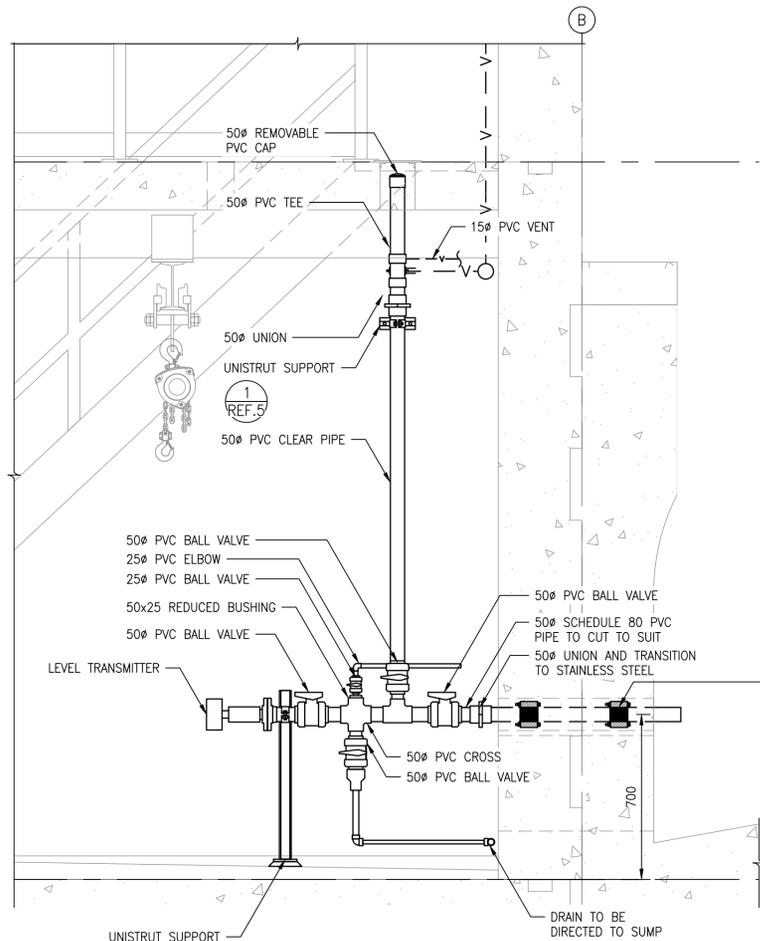


12 PRESSURE LEVEL TRANSMITTER ASSEMBLY
 REF.2,3,4 SCALE: 1:15

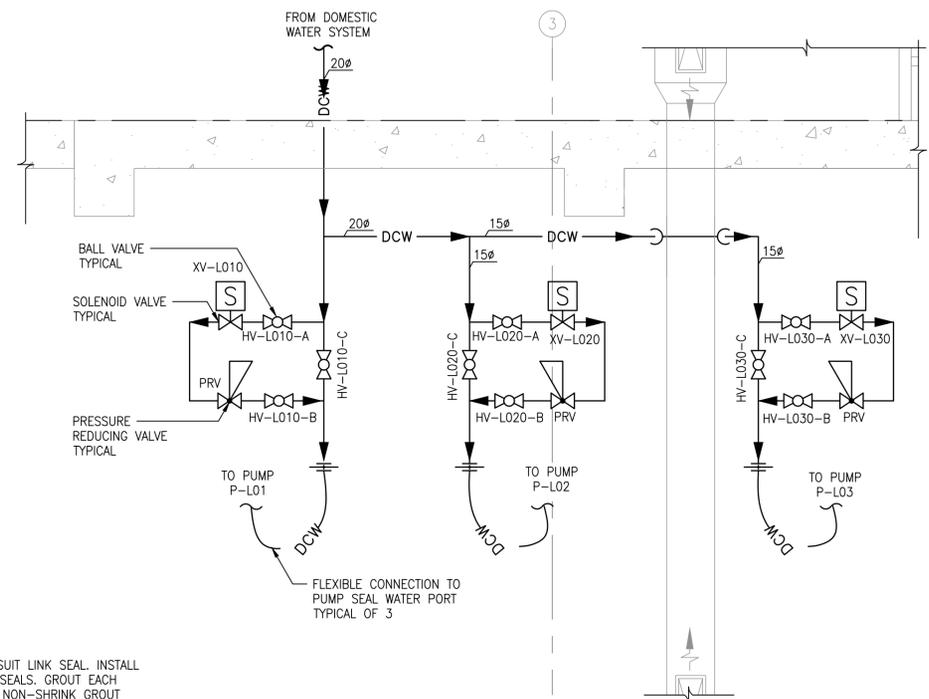

13 SEAL FLUSH WATER ASSEMBLY DETAIL
 REF.2,4 SCALE: 1:15

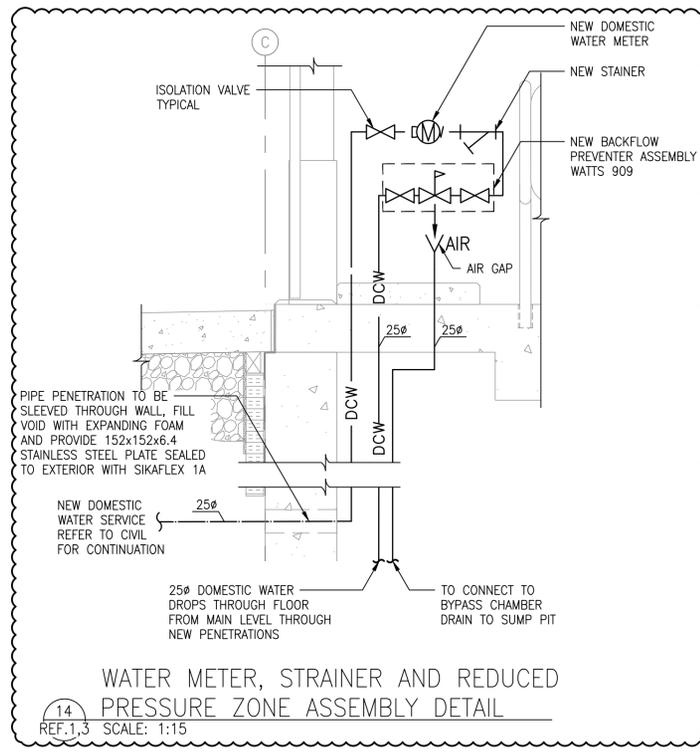

14 WATER METER, STRAINER AND REDUCED PRESSURE ZONE ASSEMBLY DETAIL
 REF.1,3 SCALE: 1:15

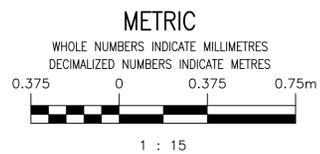

NO.	DRAWING NUMBER	REFERENCE DRAWINGS TITLE
9		
8		
7		
6		
5	1-0193L-M0006-001	MECHANICAL DETAILS
4	1-0193L-M0003-002	MECHANICAL PIPING SECTIONS NEW WORK
3	1-0193L-M0003-001	MECHANICAL PIPING SECTIONS NEW WORK
2	1-0193L-M0002-002	MECHANICAL PIPING PLANS MOTOR ROOM, COMMUNOTOR CHAMBER AND PUMP ROOM NEW WORK
1	1-0193L-M0002-001	MECHANICAL PIPING PLANS MAIN FLOOR AND LOWER LEVEL NEW WORK

ENGINEERS GEOSCIENTISTS MANITOBA
 Certificate of Authorization
 MPE, a division of Englobe Corp.
 No. 4968 Date: FEB 10, 2026

NO.	REVISIONS	DATE	DESIGN	CHECK
01	REISSUED FOR CONSTRUCTION, B.O. 1042-2025	2026-02-10	BRB	BRB
00	ISSUED FOR CONSTRUCTION, B.O. 1042-2025	2026-01-09	BRB	BRB

MPE
 a division of Englobe

DESIGNED BY: B. DRADER, B. BAKER
 CHECKED BY: B. BAKER
 DRAWN BY: J. BALVERDE
 APPROVED BY: B. BAKER
 SCALE: AS NOTED
 RELEASED FOR CONSTRUCTION BY: B. BAKER
 DATE: 2026-01-09
 CONSULTANT NO.: 8400-011-00

ENGINEER'S SEAL

 2026-02-10
 01

THE CITY OF WINNIPEG
 WATER AND WASTE DEPARTMENT

TYLEHURST LIFT STATION
 2026 UPGRADES
 MECHANICAL DETAILS

CITY DRAWING NUMBER: 1-0193L-M0006
 SHEET: 002
 REV: 01
 SIZE: A1