


A1 SIZE - 594mm x 841mm


LAST SAVE: 2026/03/06 - 3:30pm
 PATH: M:\V-DATA\B4\00 City of Winnipeg\11 - Tylehurst Lift Station Upgrades\AutoDesk\ACAD\1-0193L-B0004-002-01.dwg

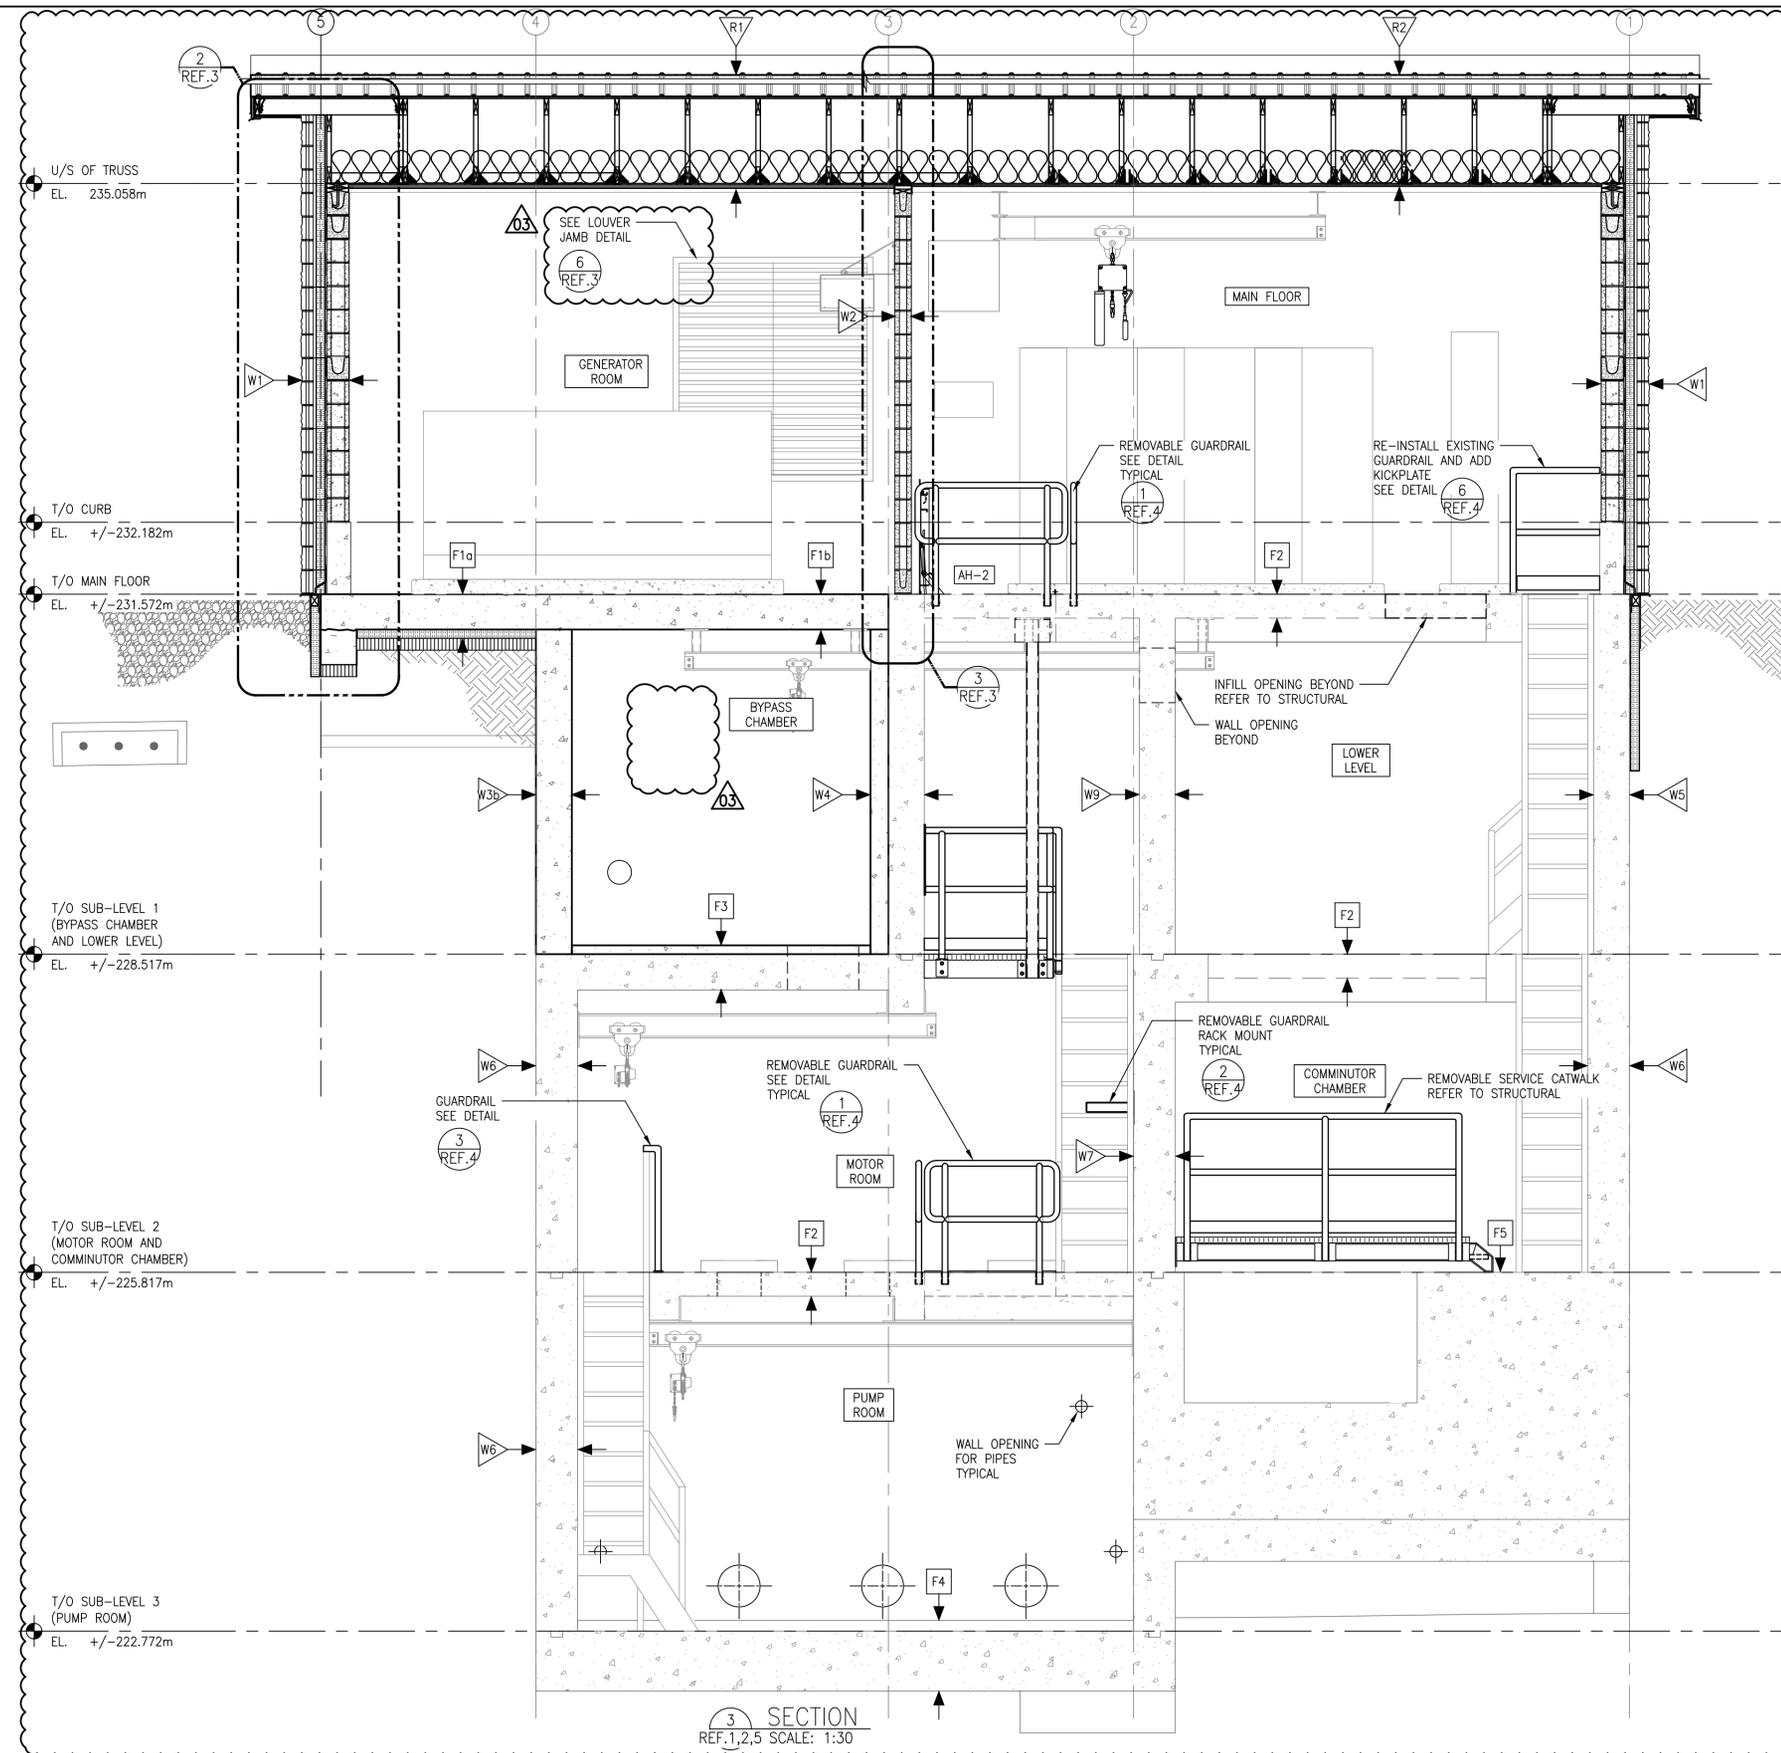

SECTION REMOVED

- GENERAL NOTES:**
- ALL ITEMS SHOWN BOLD AND BLACK INDICATE NEW CONSTRUCTION. SOLID GREY LINES INDICATE EXISTING TO REMAIN.
 - CONTRACTOR TO FIELD CONFIRM ALL DIMENSIONS. NOTE ANY DISCREPANCIES WITH ENGINEER PRIOR TO FABRICATION OR CONSTRUCTION.
 - SEE WALL, FLOOR, ROOF AND ACCESS HATCH SCHEDULES ON SHEET 1-0193L-B0007-001 FOR SPECIFICATIONS.
 - WET WELL ACCESS HATCH LADDER AND ASSOCIATED PLATES AND HARDWARE TO BE STAINLESS STEEL ASTM-A240 GRADE 304.
 - STAINLESS BOLTS TO BE ASTM F593 GRADE 304.
 - COAT ALL ALUMINUM SURFACES IN CONTACT WITH CONCRETE WITH 2 COATS BITUMEN.
 - PREPARE AND FINISH ALL CONCRETE, MASONRY AND METAL SURFACES IN ACCORDANCE WITH SECTION 09 01 90.63. FOR EXISTING STAIRS, LADDERS AND RAILS TO BE REFURBISHED, REMOVE LOOSE COATINGS AND CORROSION, PREPARE SURFACES AND REPAINT SAFETY YELLOW. FOR NEW STAIRS, LADDERS AND RAILS, PREPARE AND PAINT SAFETY YELLOW. PROVIDE RESINOUS EPOXY FLOORING PER SECTION 09 67 63 AND ANTI-GRAFFITI COATING ON EXTERIOR BRICK AND MASONRY PER SECTION 09 96 50. COLOURS AND COATING TYPE SHALL COMPLY WITH ROOM FINISH SECTION 09 01 90.63.
 - CONTRACTOR RESPONSIBLE FOR PROTECTION OF EXISTING WET WELL DURING DEMOLITION AND CONSTRUCTION.

SECTION 3
 REF. 1,2,5 SCALE: 1:30

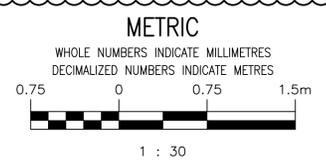

NO.	DRAWING NUMBER	REFERENCE DRAWINGS TITLE
9		
8		
7		
6		
5	1-0193L-B0003-001	ARCHITECTURAL PLAN ROOF PLAN
4	1-0193L-B0007-001	ARCHITECTURAL SCHEDULES AND DETAILS
3	1-0193L-B0006-001	ARCHITECTURAL WALL DETAILS
2	1-0193L-B0002-002	ARCHITECTURAL PLANS MOTOR ROOM, COMMUNOTOR CHAMBER AND PUMP ROOM NEW WORK
1	1-0193L-B0002-001	ARCHITECTURAL PLANS MAIN FLOOR AND LOWER LEVEL NEW WORK


**ENGINEERS
 GEOSCIENTISTS
 MANITOBA**
 Certificate of Authorization
 MPE, a division of Englobe Corp.
 No. 4968 Date: MAR 09, 2026

NO.	REVISIONS	DATE	DESIGN	CHECK
03	RE-ISSUED FOR CONSTRUCTION, B.O. 1042-2025	2026-03-09	MJB	MJB
02	ISSUED FOR CONSTRUCTION, B.O. 1042-2025	2025-01-19	MJB	02
01	RE-ISSUED FOR DEMOLITION, B.O. 1042-2025	2026-03-09	MJB	MJB
00	ISSUED FOR DEMOLITION, B.O. 1042-2025	2026-01-09	MJB	MJB

MPE
 a division of Englobe

DESIGNED BY: M. BAKER
 CHECKED BY: M. BAKER
 DRAWN BY: J. BALVERDE
 APPROVED BY: M. BAKER

SCALE: AS NOTED
 DATE: 2026-01-09
 CONSULTANT NO.: 8400-011-00

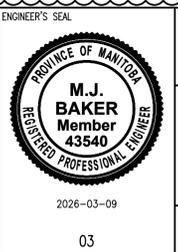

THE CITY OF WINNIPEG
 WATER AND WASTE DEPARTMENT

TYLEHURST LIFT STATION
 2026 UPGRADES
 ARCHITECTURAL SECTIONS
 BUILDING SECTIONS
 NEW WORK

CITY DRAWING NUMBER: 1-0193L-B0004
 SHEET: 002
 REV: 03
 SIZE: A1