



GENERAL NOTES:


- CONTRACTOR TO COORDINATE SIZE AND LOCATION OF PENETRATIONS WITH MECHANICAL, PROCESS, AND ELECTRICAL.
- BUILDING TO BE CONSTRUCTED TO THE NATIONAL BUILDING CODE - 2020, MANITOBA EDITION, POST DISASTER.
- SUPPLY AND INSTALL PRE-FINISHED STANDING SEAM ROOF SYSTEM COMPLETE ALL REQUIRED FLASHING, EDGE, END AND CORNER DETAILS TO PROVIDE A WATER TIGHT ROOF SYSTEM. OWNER TO SELECT COLOUR FROM STANDARD RANGE.
- CONTRACTOR TO FIELD VERIFY ALL DIMENSIONS AND EXISTING BUILDING CONSTRUCTION. NOTE ANY DISCREPANCIES WITH ENGINEER PRIOR TO CONSTRUCTION OR FABRICATION.
- DOWNSPOUT TO BE ATTACHED TO MASONRY WALL.

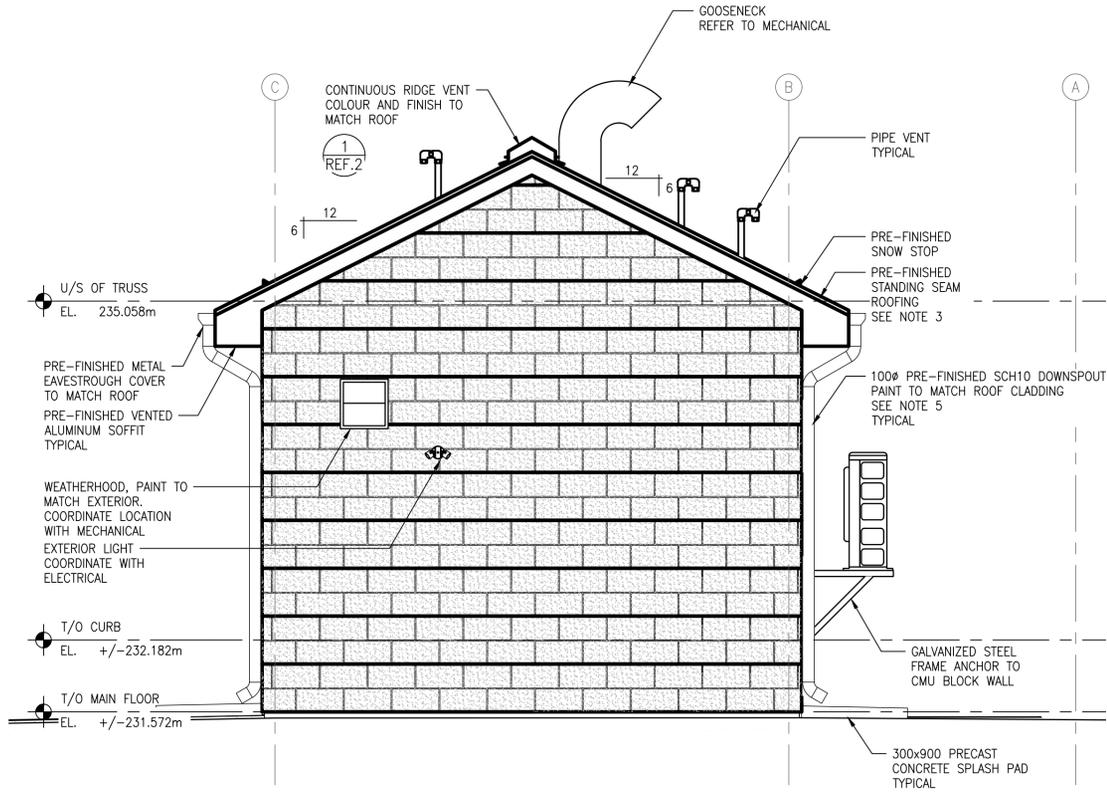


1 NORTH BUILDING ELEVATION
 SCALE: 1:30

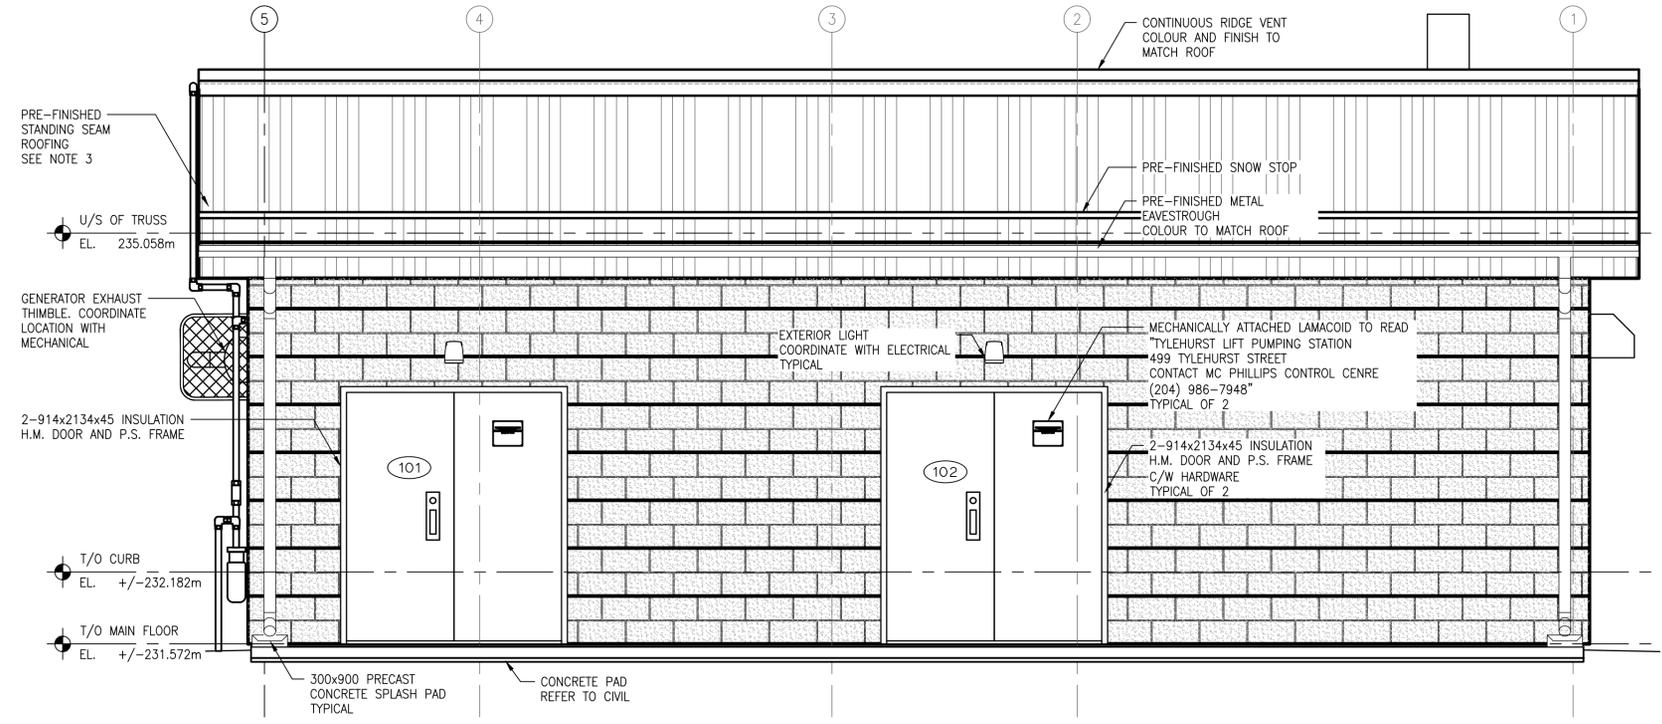


2 WEST BUILDING ELEVATION
 SCALE: 1:30

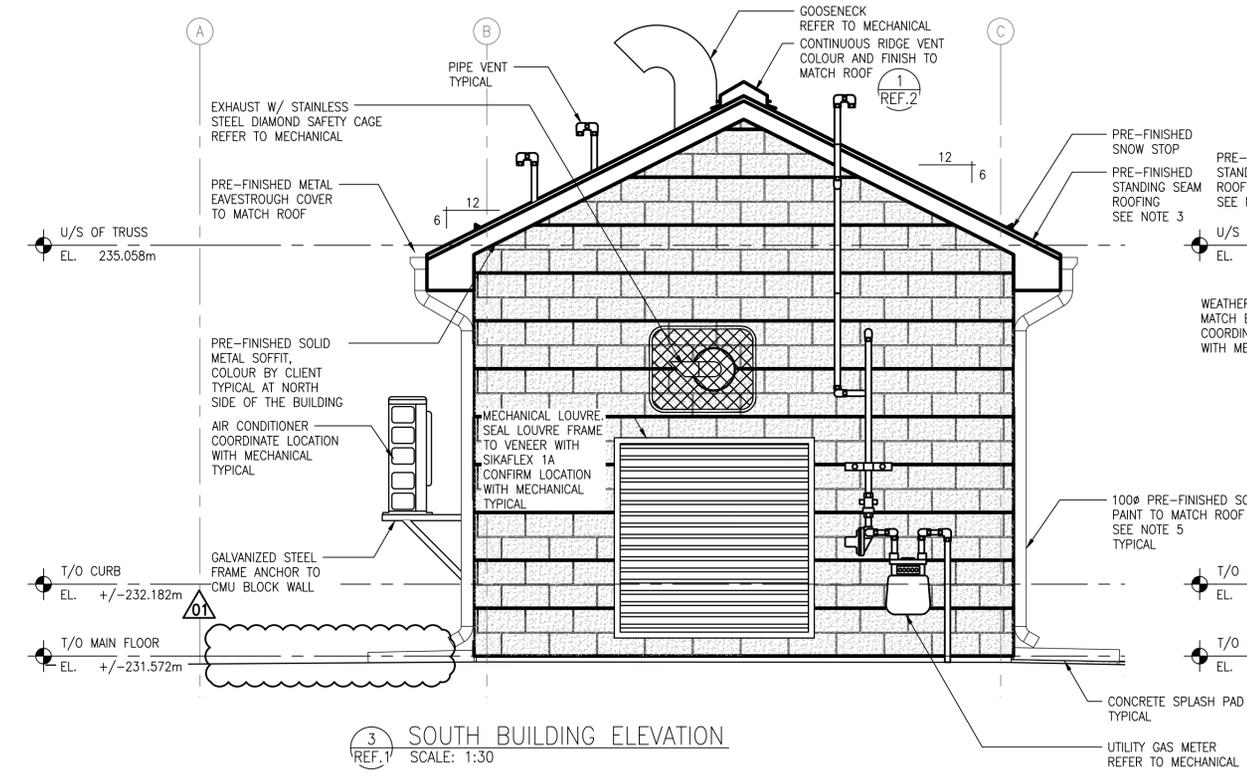

3 SOUTH BUILDING ELEVATION
 SCALE: 1:30

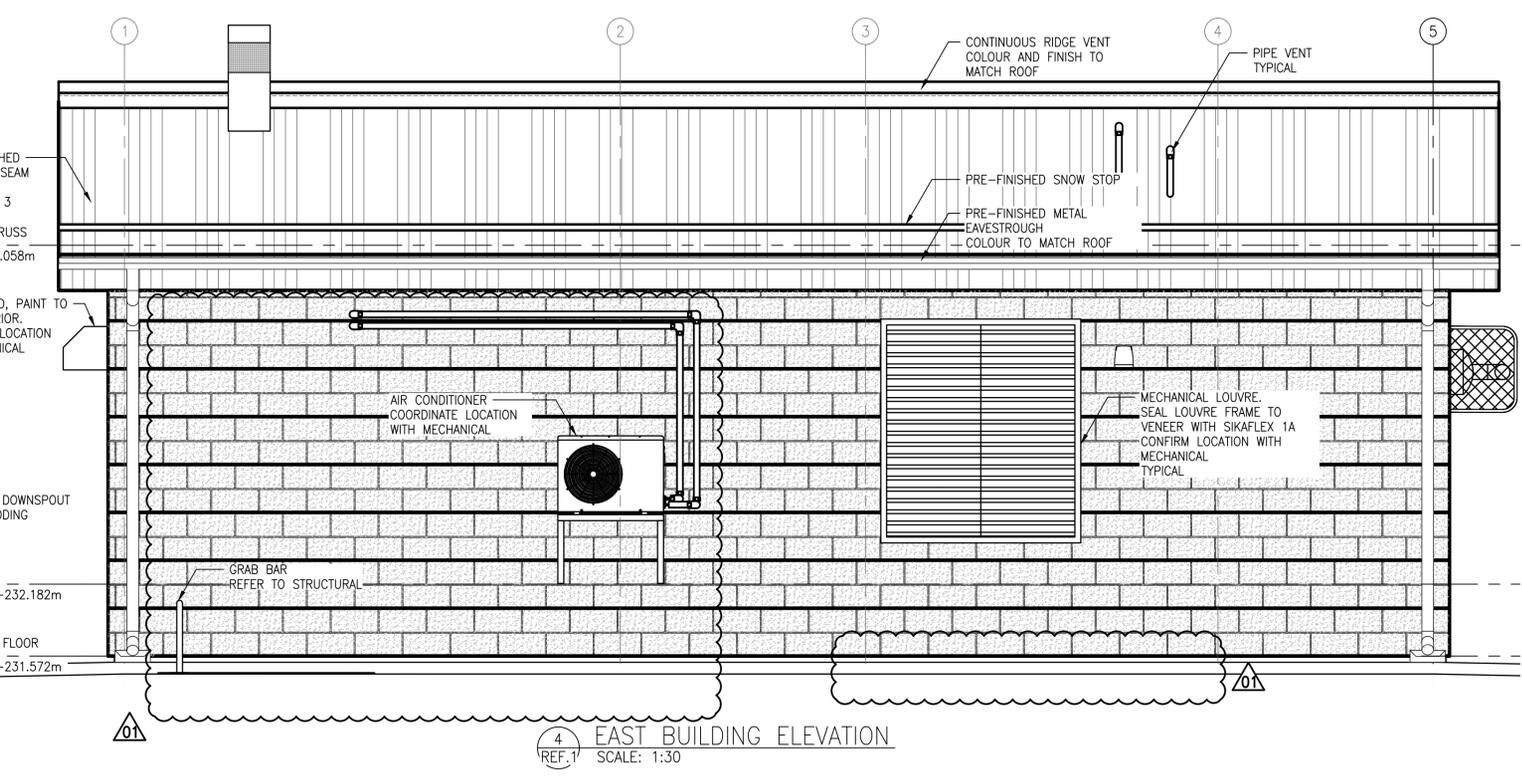


4 EAST BUILDING ELEVATION
 SCALE: 1:30

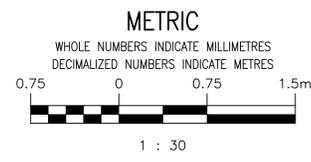

ENGINEERS GEOSCIENTISTS MANITOBA
 Certificate of Authorization
 MPE, a division of Englobe Corp.
 No. 4968 Date: MAR 09, 2026

NO.	REVISIONS	DATE	DESIGN	CHECK
01	RE-ISSUED FOR CONSTRUCTION, B.O. 1042-2025	2026-03-09	MJB	MJB
00	ISSUED FOR CONSTRUCTION, B.O. 1042-2025	2026-01-09	MJB	MJB

MPE a division of Englobe	
DESIGNED BY: M. BAKER	CHECKED BY: M. BAKER
DRAWN BY: J. BALVERDE	APPROVED BY: M. BAKER
SCALE: AS NOTED	RELEASED FOR CONSTRUCTION BY:
DATE: 2026-01-09	DATE:
CONSULTANT NO.: 8400-011-00	

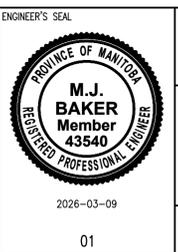

THE CITY OF WINNIPEG
 WATER AND WASTE DEPARTMENT

TYLEHURST LIFT STATION
 2026 UPGRADES
 ARCHITECTURAL
 BUILDING ELEVATIONS

CITY DRAWING NUMBER 1-0193L-B0005	SHEET 001	REV. 01	SIZE A1
---	---------------------	-------------------	-------------------

NO.	DRAWING NUMBER	REFERENCE DRAWINGS TITLE
2	1-0193L-B0003-001	ARCHITECTURAL PLAN ROOF PLAN
1	1-0193L-B0002-001	ARCHITECTURAL PLANS MAIN FLOOR AND LOWER LEVEL NEW WORK