

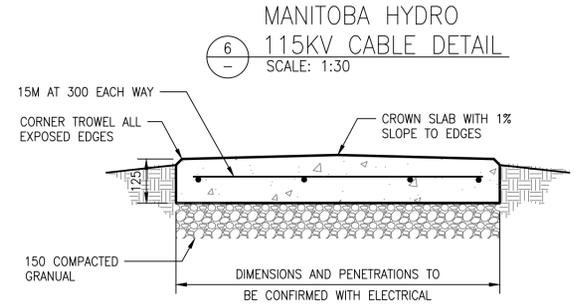
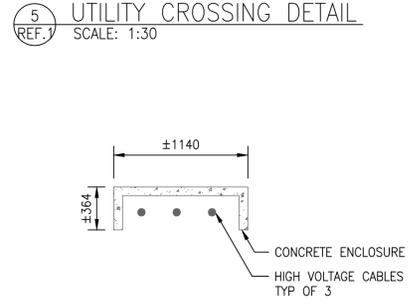


- NOTES:**
- FOR INFORMATION REGARDING GENERAL NOTES, UTILITIES, SYMBOLS, AND ABBREVIATIONS, REFER TO THE LEGEND AND ABBREVIATIONS DRAWING.
 - READ THE CIVIL DRAWINGS IN CONJUNCTION WITH THE ARCHITECTURAL, STRUCTURAL, MECHANICAL, AND ELECTRICAL DRAWINGS. COORDINATE TIE-INS AND OTHER ITEMS OF WORK. NOTIFY THE OWNER'S REPRESENTATIVE OF ANY DESIGN VARIANCES.
 - ALL WORK TO BE COMPLETED TO THE LATEST CITY OF WINNIPEG DESIGN STANDARDS AND CONSTRUCTION SPECIFICATIONS.
 - ALL FILL MATERIAL TO BE CLASS 1 BACKFILL ACCORDING TO CW 2030.
 - GRADE TO SLOPE 1% AWAY FROM CONCRETE SLAB UNLESS NOTED OTHERWISE.
 - CONCRETE DRIVEWAY TO BE CONSTRUCTED TO THE REQUIREMENTS OF CW 3310 AT MINIMUM. GRAVEL DRIVEWAY TO BE CONSTRUCTED TO THE REQUIREMENTS OF CW 3150 AND CW 3110 AT MINIMUM.
 - CONTRACTOR TO NOT USE VIBRATORY COMPACTION OVER THE HIGH VOLTAGE CABLES.

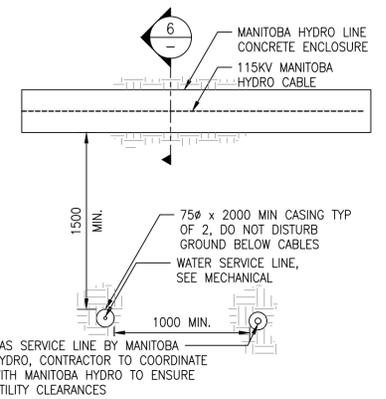

NO.	DRAWING NUMBER	REFERENCE DRAWINGS TITLE
2	1-0193L-C0003-001	CIVIL BYPASS PUMPING AND DETAILS PLANS SECTIONS
1	1-0193L-C0001-001	CIVIL SITE SERVICES PLAN

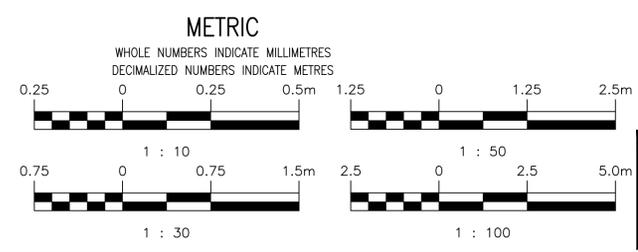

ENGINEERS GEOSCIENTISTS MANITOBA
Certificate of Authorization
MPE, a division of Englobe Corp.
No. 4968 Date: MAR 09, 2026

NO.	REVISIONS	DATE	DESIGN	CHECK
01	RE-ISSUED FOR CONSTRUCTION, B.O. 1042-2025	2026-03-09	MJB	MJB
00	ISSUED FOR CONSTRUCTION, B.O. 1042-2025	2026-01-09	MJB	MJB

MPE
a division of Englobe

DESIGNED BY: N. FALK
DRAWN BY: D. MCMILLAN
SCALE: AS NOTED

CHECKED BY: M. BAKER
APPROVED BY: M. BAKER
RELEASED FOR CONSTRUCTION BY: M. BAKER
DATE: 2026-01-09

CONSULTANT NO.: 8400-011-00

ENGINEER'S SEAL
M.J. BAKER
Member 43540
REGISTERED PROFESSIONAL ENGINEER
2026-03-09

THE CITY OF WINNIPEG
WATER AND WASTE DEPARTMENT

TYLEHURST LIFT STATION
2026 UPGRADES
CIVIL
LOT GRADING PLAN AND SITE DRAINAGE

CITY DRAWING NUMBER: 1-0193L-C0002
SHEET: 001
REV: 01
SIZE: A1