



MAIN FLOOR- DEMOLITION PLAN (EL. 231.572m)
 SCALE: 1:30

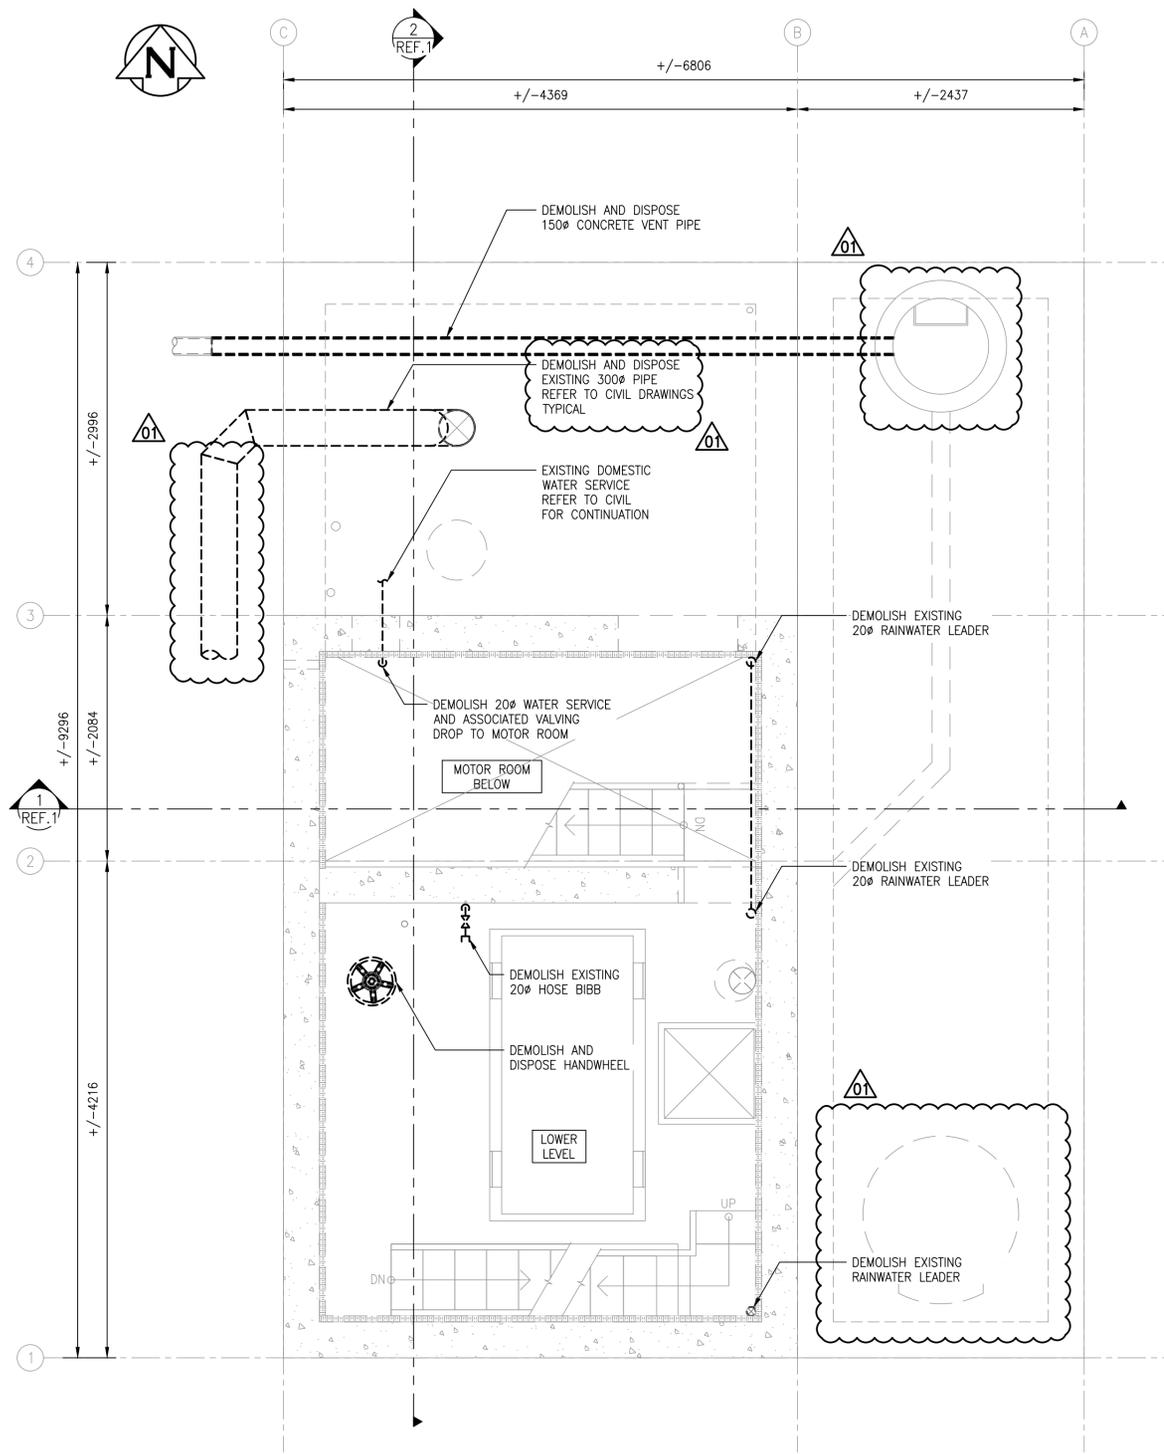

LOWER LEVEL- DEMOLITION PLAN (EL. 228.517m)
 SCALE: 1:30

- GENERAL NOTES:**
1. ALL ITEMS SHOWN BOLD DASHED LINES INDICATE ITEMS TO BE DEMOLISHED. SOLID AND GREY LINES INDICATE EXISTING TO REMAIN.
 2. REMOVE AND DISPOSE ALL DEMOLISHED MATERIAL AT APPROVED DISPOSAL SITE.

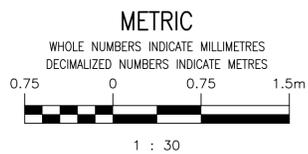

NO.	REVISIONS	DATE	DESIGN	CHECK
01	RE-ISSUED FOR DEMOLITION, B.O. 1042-2025	2026-03-09	MJB	MJB
00	ISSUED FOR DEMOLITION, B.O. 1042-2025	2026-01-09	BRB	BRB

MPE a division of Englobe	
DESIGNED BY: B. BAKER	CHECKED BY: B. BAKER
DRAWN BY: J. BALVERDE	APPROVED BY: B. BAKER
SCALE: AS NOTED	RELEASED FOR CONSTRUCTION BY: DATE:
CONSULTANT NO.: 8400-011-00	



THE CITY OF WINNIPEG WATER AND WASTE DEPARTMENT		
TYLEHURST LIFT STATION 2026 UPGRADES MECHANICAL PIPING PLANS MAIN FLOOR AND LOWER LEVEL DEMOLITION		
CITY DRAWING NUMBER 1-0193L-M0002	SHEET 001	REV. SIZE 01 A1