



LAST SAVE: 2026/03/06 - 3:04pm  
 PATH: M:\N-Data\84\00 City of Winnipeg\11 - Tylehurst Lift Station Upgrades\AutoDesk\ACAD\1-0193L-M0002-002-00.dwg  
 A1 SIZE - 594mm x 841mm

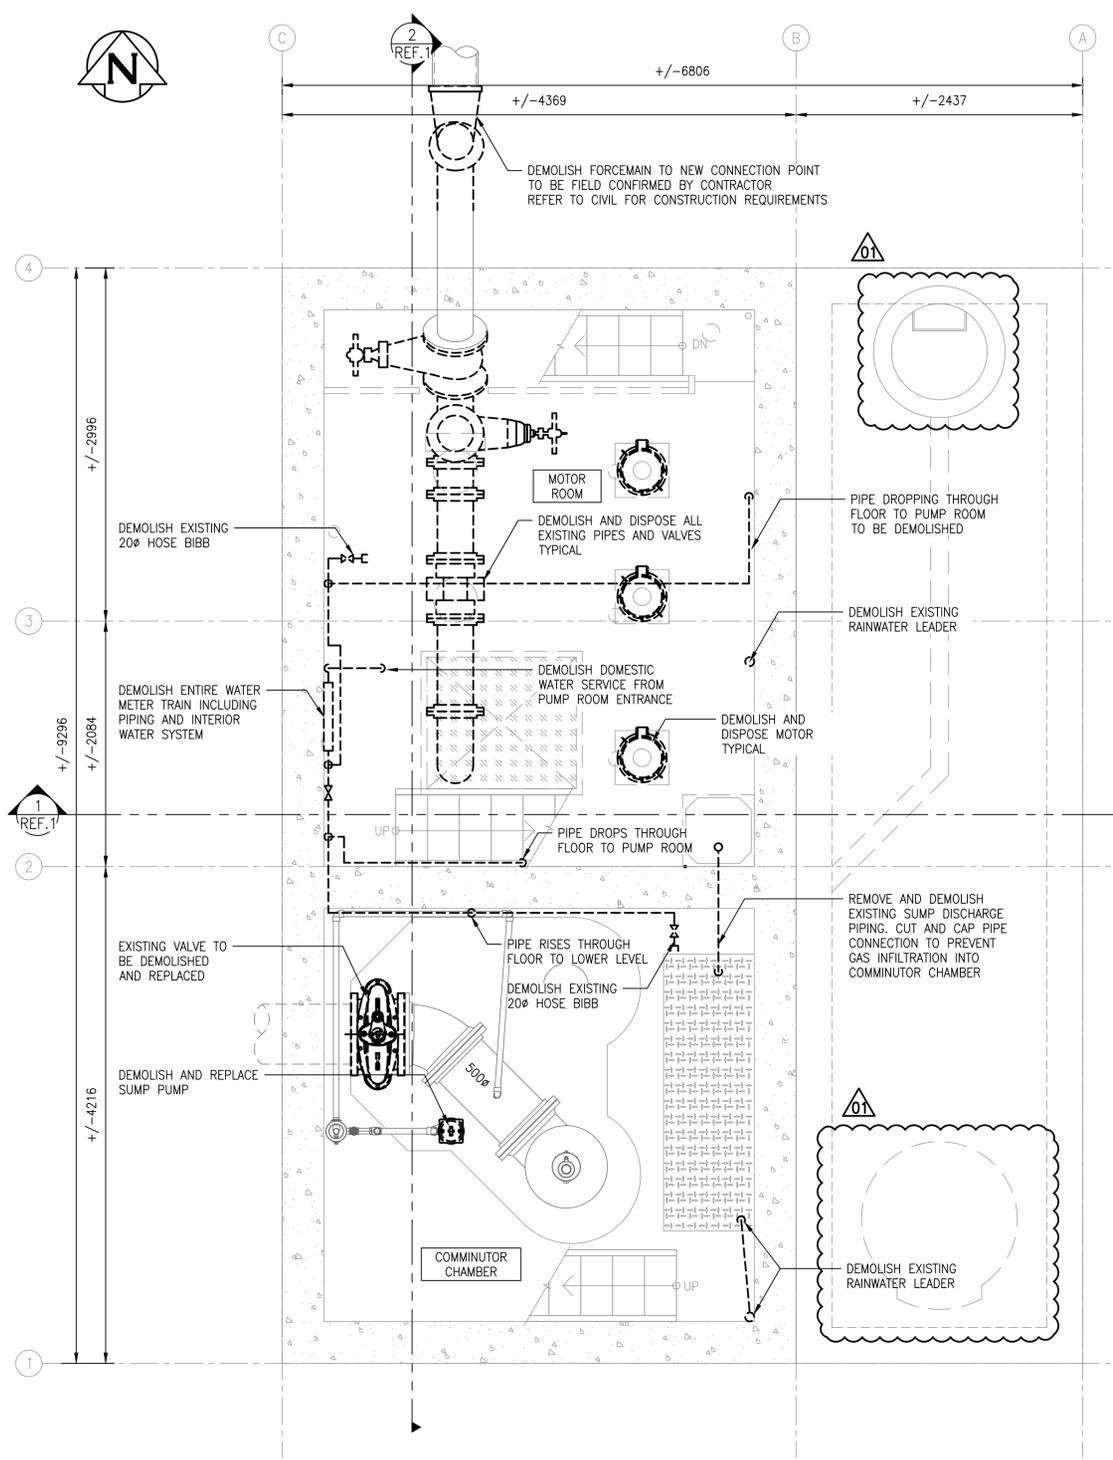


MOTOR ROOM AND COMMUNOTOR CHAMBER – DEMOLITION PLAN (EL. 225.817m)  
SCALE: 1:30

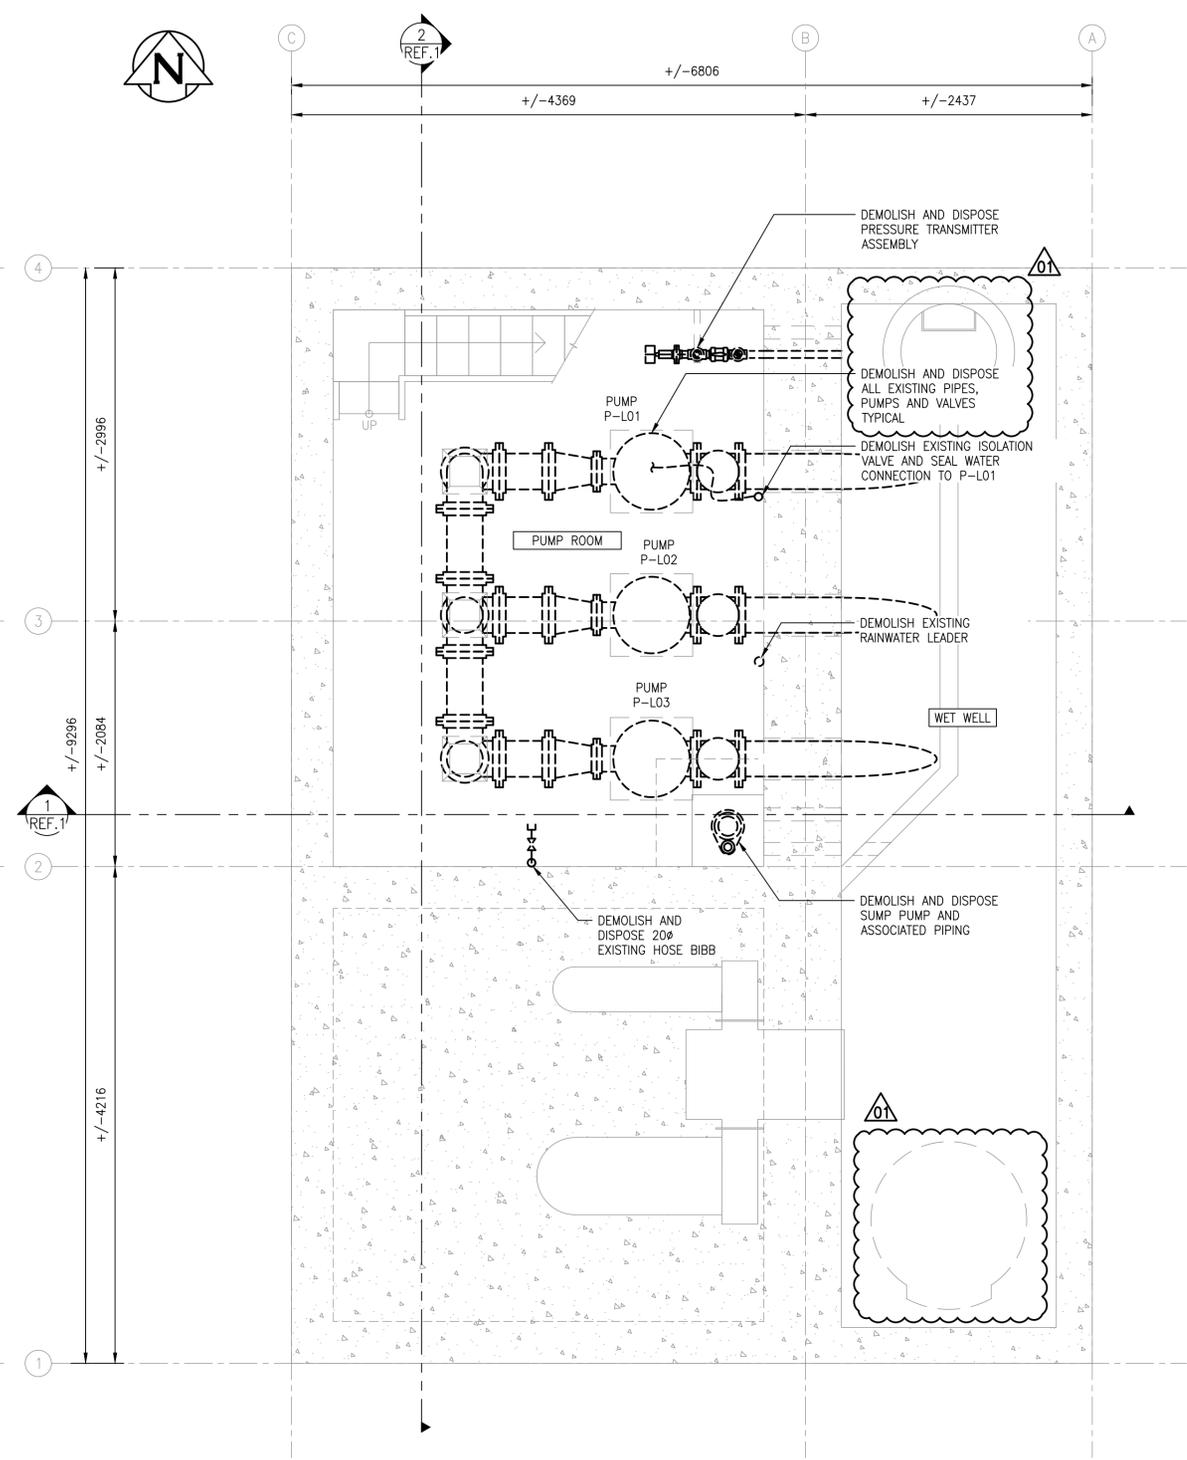

PUMP ROOM AND WET WELL – DEMOLITION PLAN (EL. 222.772m)  
SCALE: 1:30

- GENERAL NOTES:**
1. ALL ITEMS SHOWN BOLD DASHED LINES INDICATE ITEMS TO BE DEMOLISHED. SOLID AND GREY LINES INDICATE EXISTING TO REMAIN.
  2. REMOVE AND DISPOSE ALL DEMOLISHED MATERIAL AT APPROVED DISPOSAL SITE.

9		
8		
7		
6		
5		
4		
3		
2		
1	1-0193L-M0003-001	MECHANICAL PIPING SECTIONS DEMOLITION
NO.	DRAWING NUMBER	REFERENCE DRAWINGS TITLE

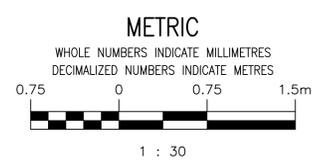

**ENGINEERS  
GEOSCIENTISTS  
MANITOBA**  
 Certificate of Authorization  
 MPE, a division of Englobe Corp.  
 No. 4968 Date: **MAR 09, 2026**

NO.	REVISIONS	DATE	DESIGN	CHECK
01	RE-ISSUED FOR DEMOLITION, B.O. 1042-2025	2026-03-09	MJB	MJB
00	ISSUED FOR DEMOLITION, B.O. 1042-2025	2026-01-09	BRB	BRB

a division of Englobe

DESIGNED BY: B. BAKER	CHECKED BY: B. BAKER
DRAWN BY: J. BALVERDE	APPROVED BY: B. BAKER
SCALE: AS NOTED	RELEASED FOR CONSTRUCTION BY: DATE:
DATE: 2026-01-09	DATE:
CONSULTANT NO.: 8400-011-00	

ENGINEER'S SEAL  
  
 2026-03-09  
 01

THE CITY OF WINNIPEG  
 WATER AND WASTE DEPARTMENT

TYLEHURST LIFT STATION  
 2026 UPGRADES  
 MECHANICAL PIPING PLANS  
 MOTOR ROOM, COMMUNOTOR CHAMBER AND PUMP ROOM  
 DEMOLITION

CITY DRAWING NUMBER	SHEET	REV.	SIZE
1-0193L-M0002	002	01	A1