



1 SECTION
 REF.1,2 SCALE: 1:30

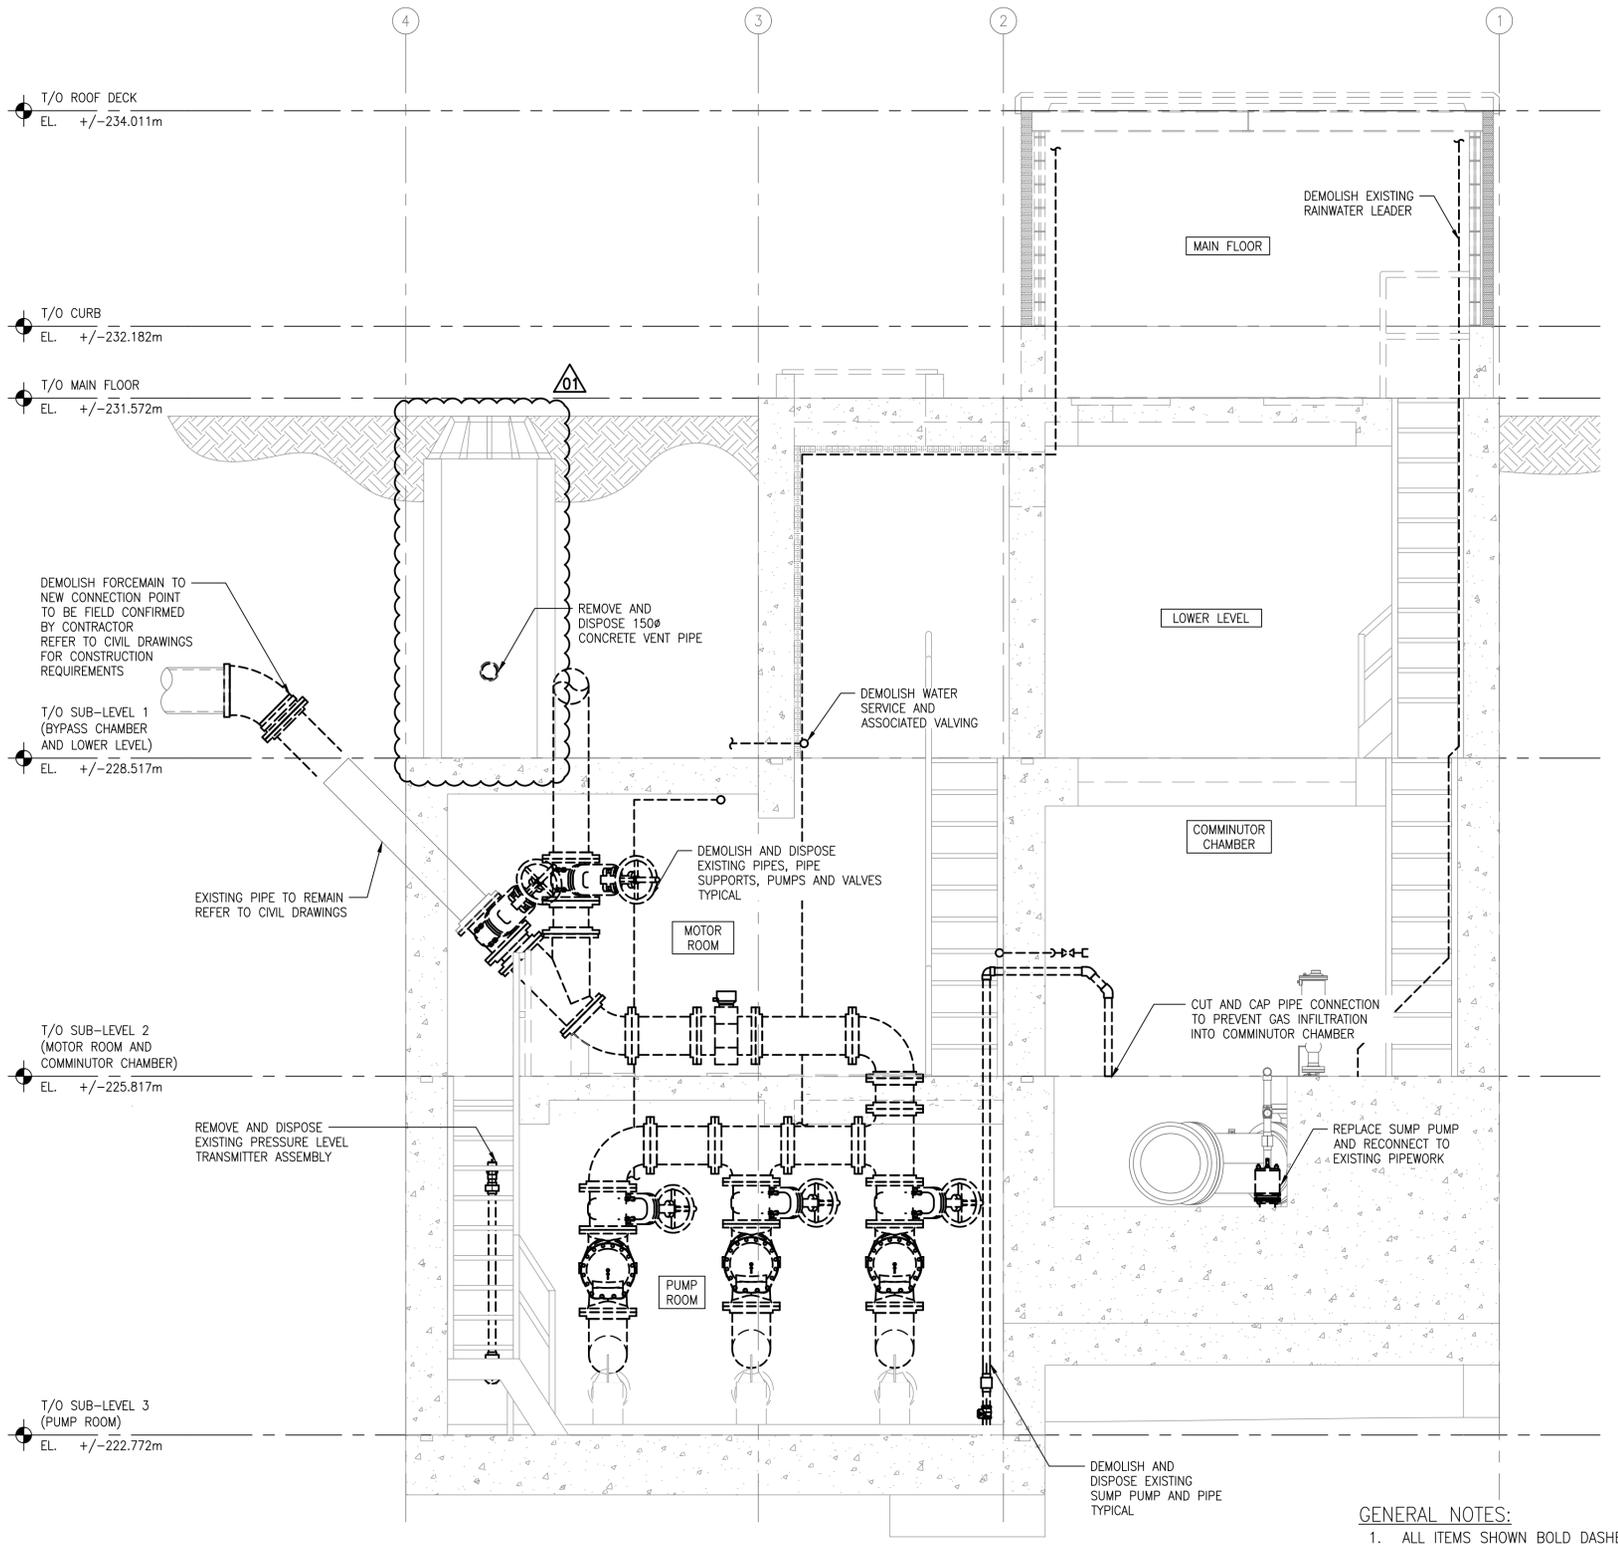

2 SECTION
 REF.1,2 SCALE: 1:30

- GENERAL NOTES:**
- ALL ITEMS SHOWN BOLD DASHED LINES INDICATE ITEMS TO BE DEMOLISHED. SOLID AND GREY LINES INDICATE EXISTING TO REMAIN.
 - REMOVE AND DISPOSE ALL DEMOLISHED MATERIAL AT APPROVED DISPOSAL SITE.

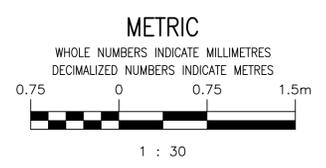

9		
8		
7		
6		
5		
4		
3		
2	1-0193L-M0002-002	MECHANICAL PIPING PLANS MOTOR ROOM, COMMUNOTOR CHAMBER AND PUMP ROOM DEMOLITION
1	1-0193L-M0002-001	MECHANICAL PIPING PLANS MAIN FLOOR AND LOWER LEVEL DEMOLITION
NO.	DRAWING NUMBER	REFERENCE DRAWINGS TITLE

**ENGINEERS
 GEOSCIENTISTS
 MANITOBA**
 Certificate of Authorization
 MPE, a division of Englobe Corp.
 No. 4968 Date: **MAR 09, 2026**

NO.	REVISIONS	DATE	DESIGN	CHECK
01	RE-ISSUED FOR DEMOLITION, B.O. 1042-2025	2026-03-09	BRB	BRB
00	ISSUED FOR DEMOLITION, B.O. 1042-2025	2026-01-09	BRB	BRB

MPE
 a division of Englobe

DESIGNED BY: B. BAKER
 CHECKED BY: B. BAKER
 DRAWN BY: J. BALVERDE
 APPROVED BY: B. BAKER

SCALE: AS NOTED
 DATE: 2026-01-09
 CONSULTANT NO.: 8400-011-00

ENGINEER'S SEAL
B. BAKER
 Member
 46231
 REGISTERED PROFESSIONAL ENGINEER
 2026-03-09

THE CITY OF WINNIPEG
 WATER AND WASTE DEPARTMENT

Winnipeg

TYLEHURST LIFT STATION
 2026 UPGRADES
 MECHANICAL PIPING SECTIONS
 DEMOLITION

CITY DRAWING NUMBER
1-0193L-M0003

SHEET REV. SIZE
 001 01 A1