

PUMP FLOOR FIRE ALARM PLAN - ELEV 229.220
SCALE: 1:75



SCALE: 1:1

DRAWING NUMBER	REFERENCE DRAWINGS
1-0650M-E0058	ELECTRICAL FIRE ALARM, LEGEND AND DETAILS
1-0650M-E0063	RISER DIAGRAM, NOTIFICATION SYSTEM
1-0650M-E0062	RISER DIAGRAM, DETECTION SYSTEM

METRIC
WHOLE NUMBERS INDICATE MILLIMETRES
DECIMALIZED NUMBERS INDICATE METRES



0.0 0.75 1.5 3.0 4.0

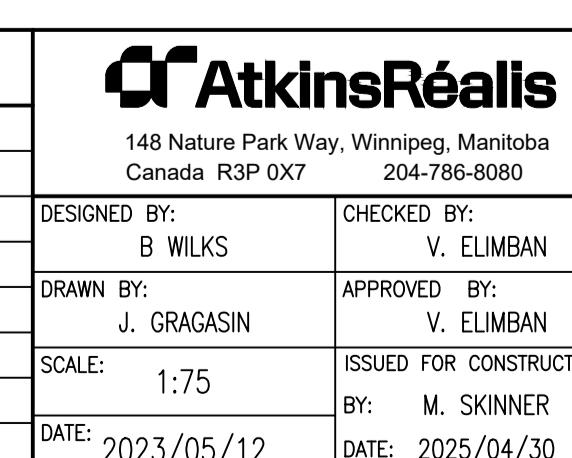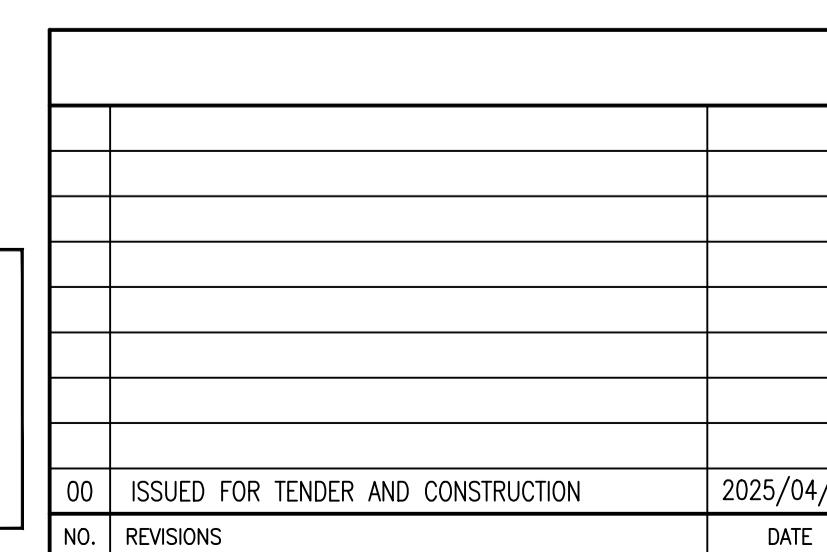

ENGINEER'S SEAL

