


NOTES:

1. DRAWING 1-0650M-A0024 REPRESENTS THE PREVIOUS P&ID. MOST EXISTING DOCUMENTATION IS BASED ON THE IDENTIFICATION SHOWN IN PREVIOUS P&ID.
2. AE-C9200 AND AE-C9201 ARE DESIGNATED AS HZ-920-ASH-1 AND HZ-920-ASH-2 RESPECTIVELY IN SOME EXISTING DOCUMENTATION.

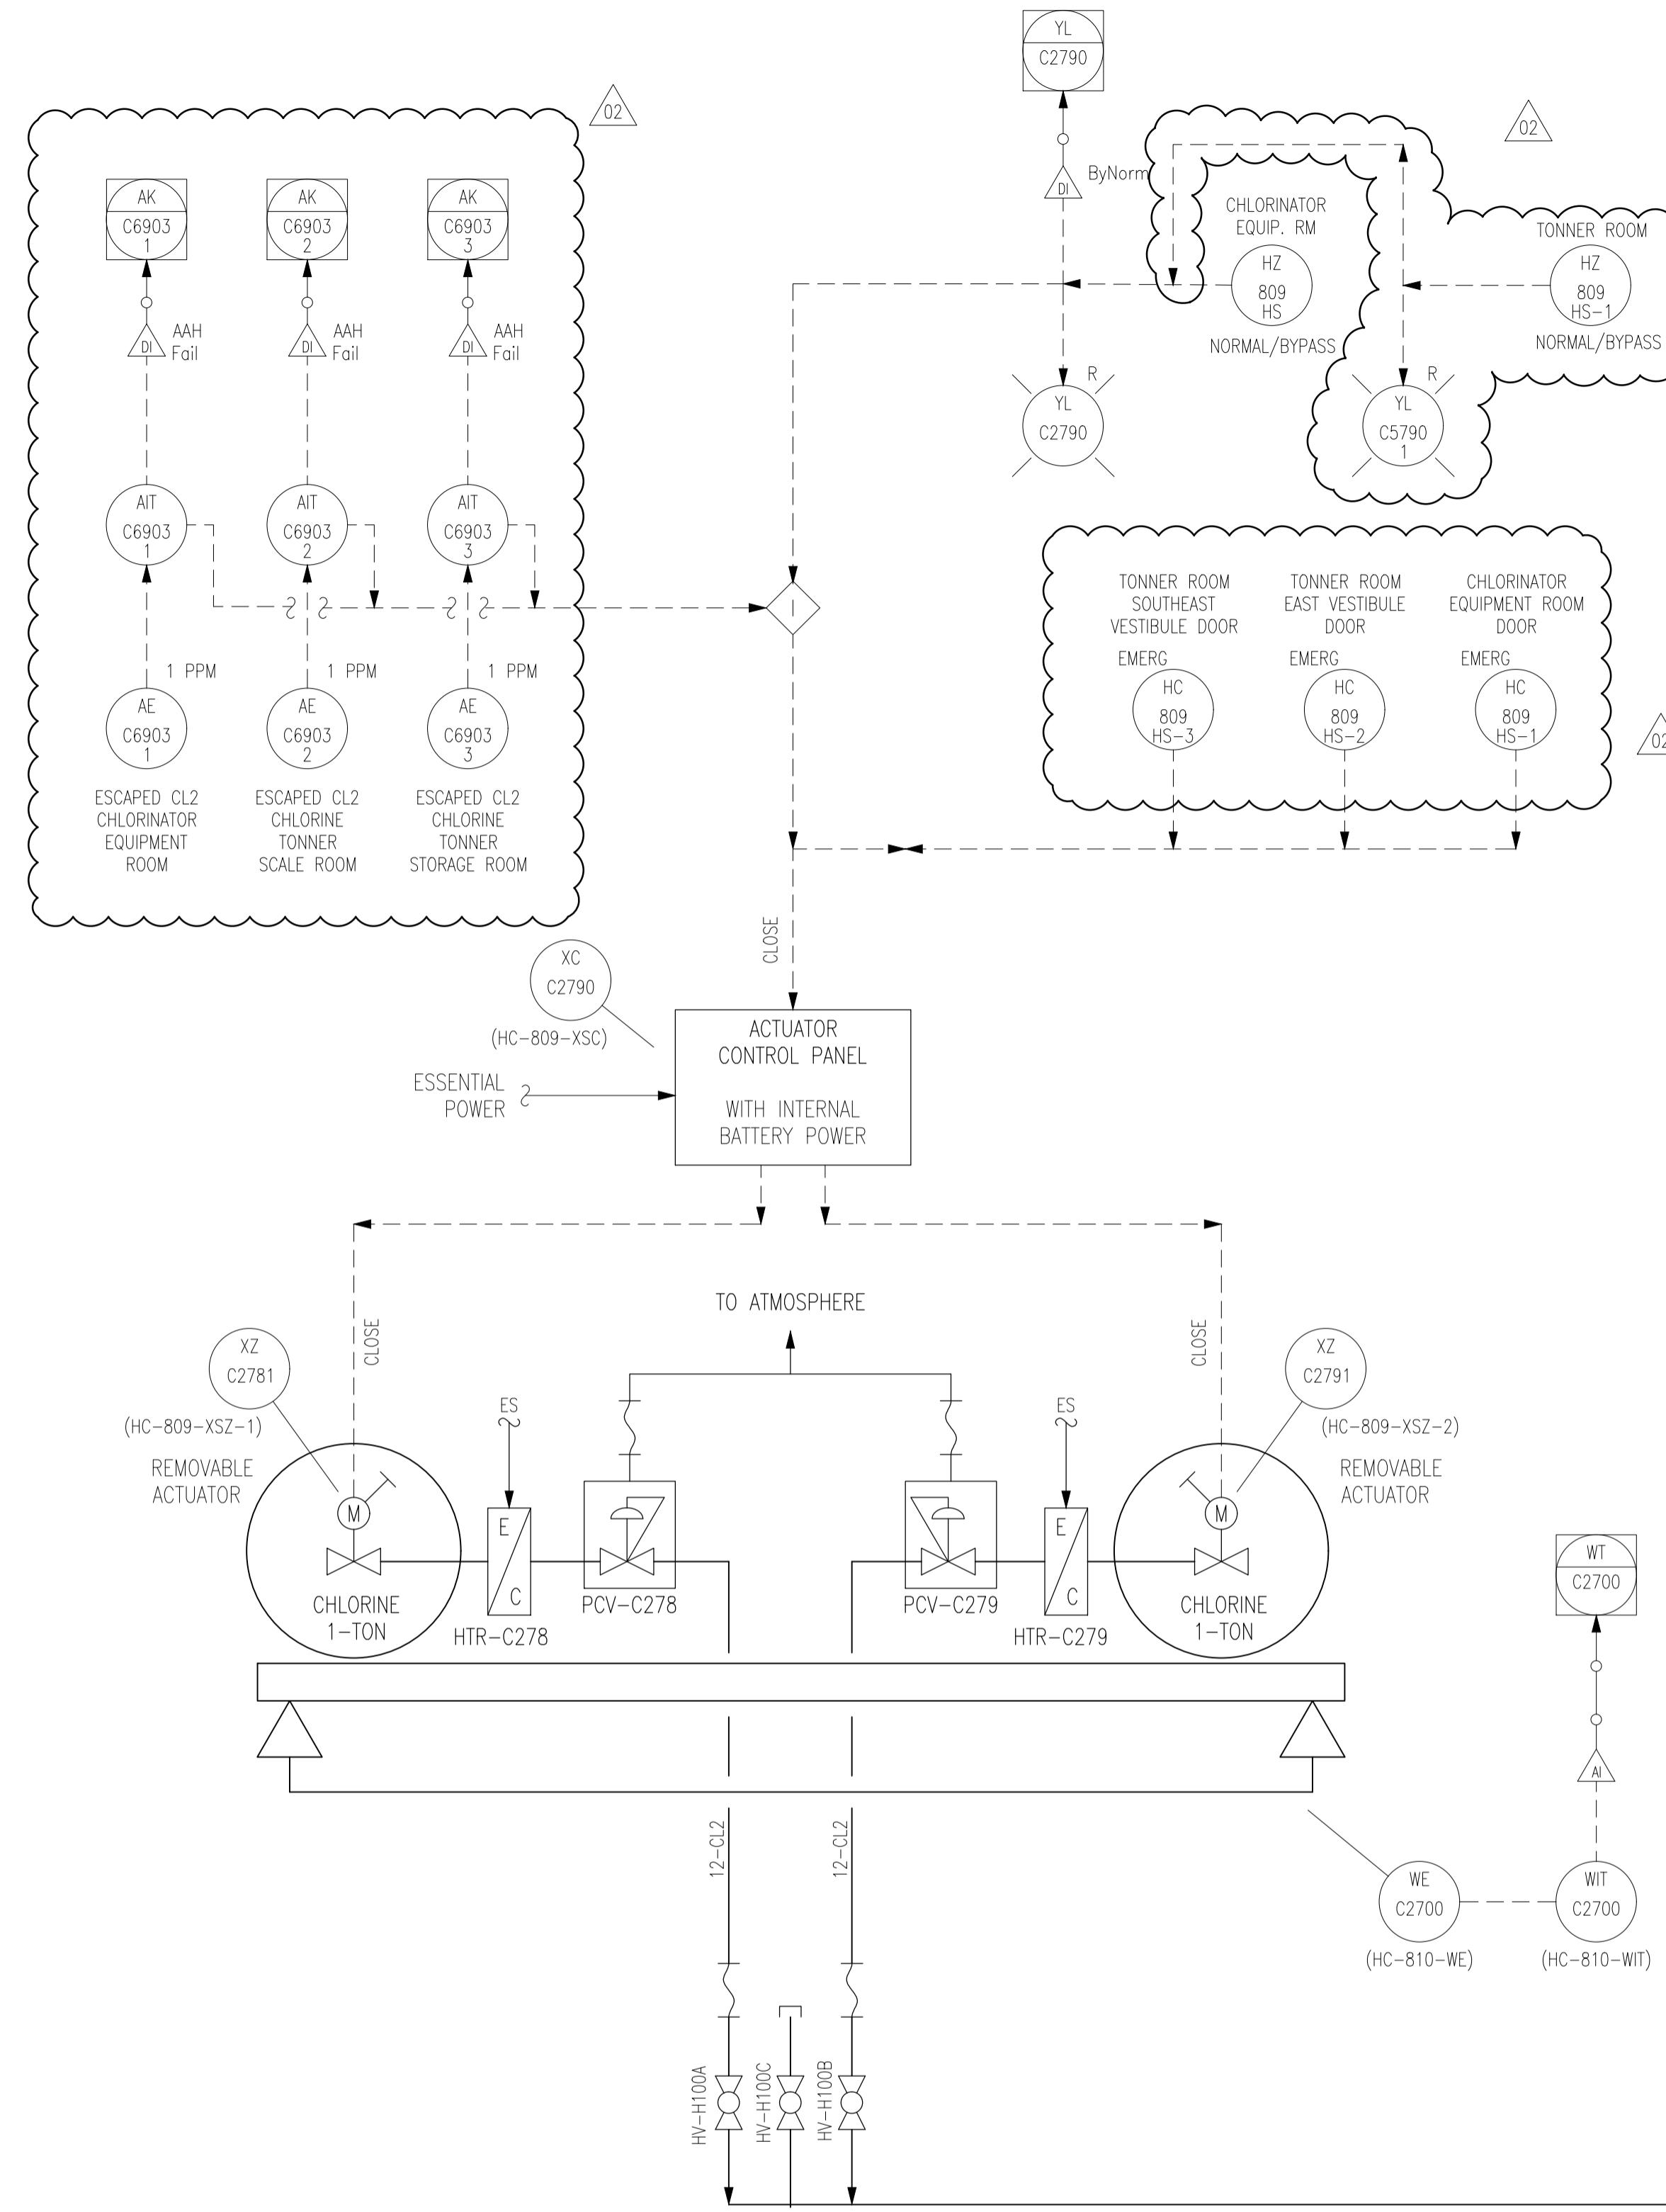

AtkinsRéalis		ENGINEER'S SEAL
DESIGNED BY:	CHECKED BY:	
EXISTING	T. CHURCH	
DRAWN BY:	APPROVED BY:	
S. FUNK	E. RYCZKOWSKI	
SCALE: NTS	ISSUED FOR CONSTRUCTION	
02 ISSUED FOR TENDER AND CONSTRUCTION	2025/04/30	BY: M. SKINNER
01 REVISED DWG	2019/09/04	DATE: 2013/01/28
00 ISSUED FOR CITY USE	2013/11/29	DATE: 2025/04/30
NO. REVISIONS	DATE	CONSULTANT NO.: 611003-0000-49DD-XXXX
	DESIGN	
	CHECK	

THE CITY OF WINNIPEG		WATER AND WASTE DEPARTMENT
	Winnipeg	
HURST PUMPING STATION	CHLORINE EMERGENCY ISOLATION SYSTEM	
PROCESS & INSTRUMENTATION DIAGRAM	CHLORINE CYLINDER SHUTOFF VALVES	
CITY DRAWING NUMBER	SHEET	REV.
1-0650M-P0024	001	02
SIZE	A1	