




PLAN OF EFFLUENT DISTRIBUTION CHAMBER No. 1
SCALE 1:50

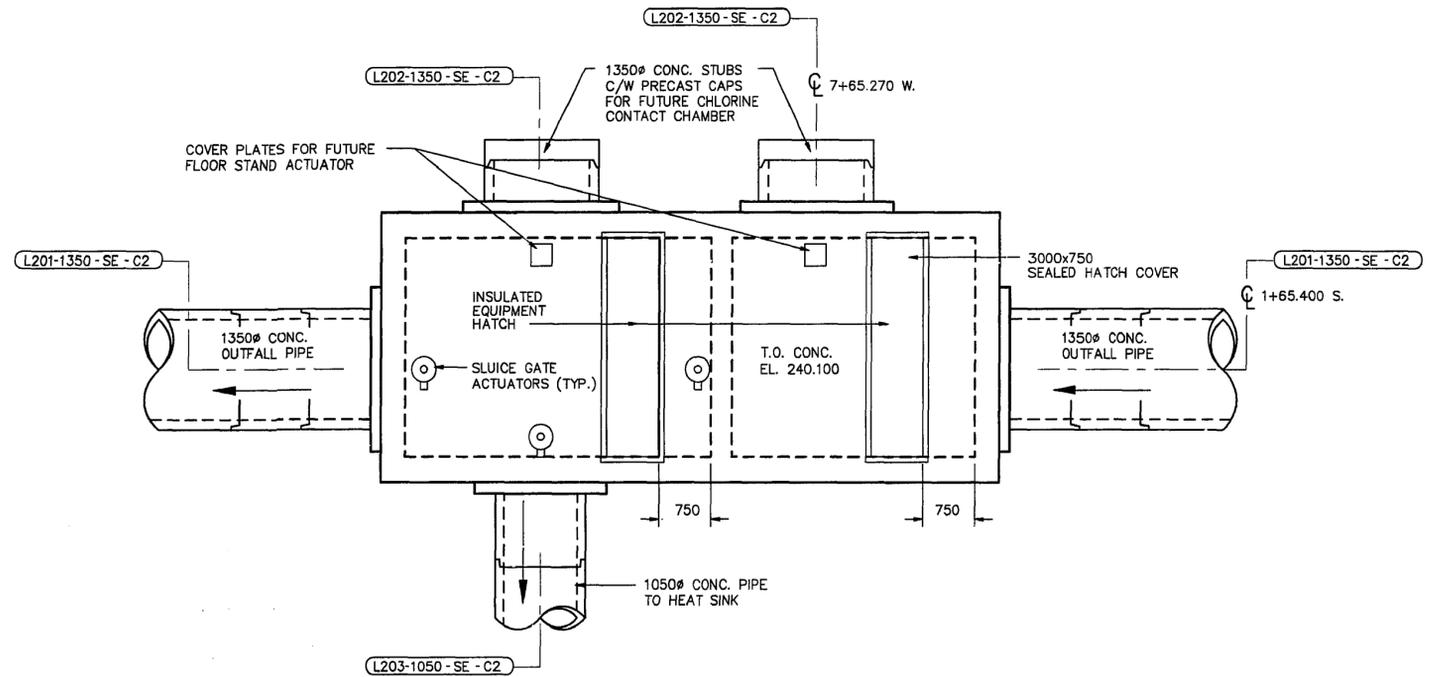


ROOF PLAN OF EFFLUENT DISTRIBUTION CHAMBER No. 1
SCALE 1:50

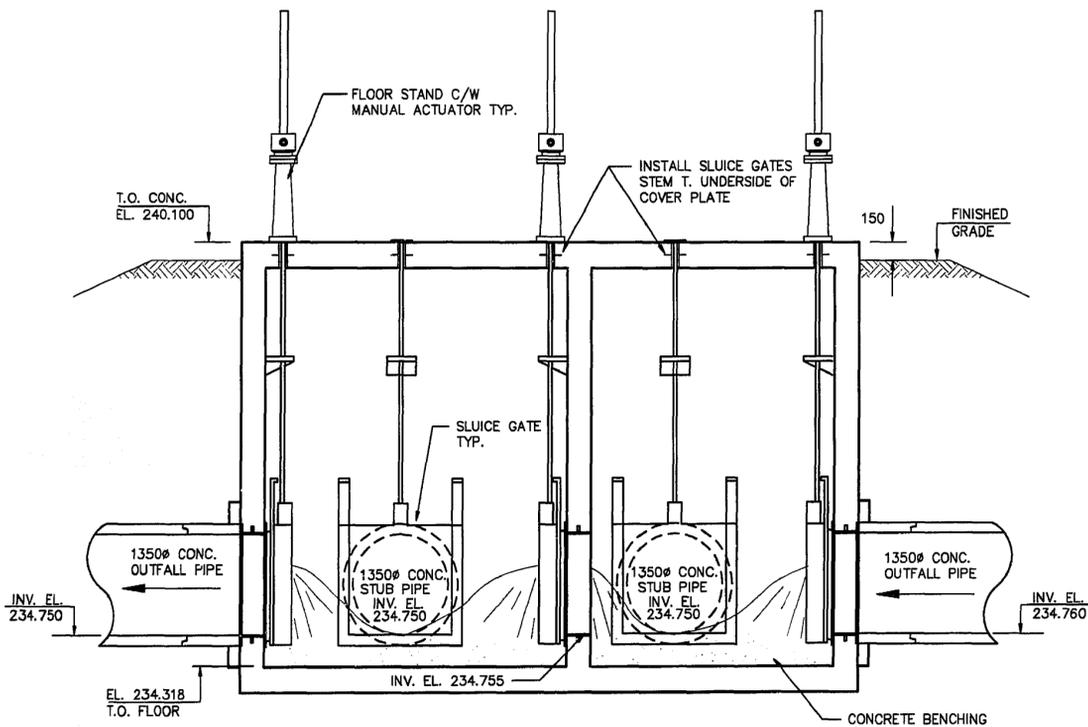

1 SECTION
SCALE 1:50

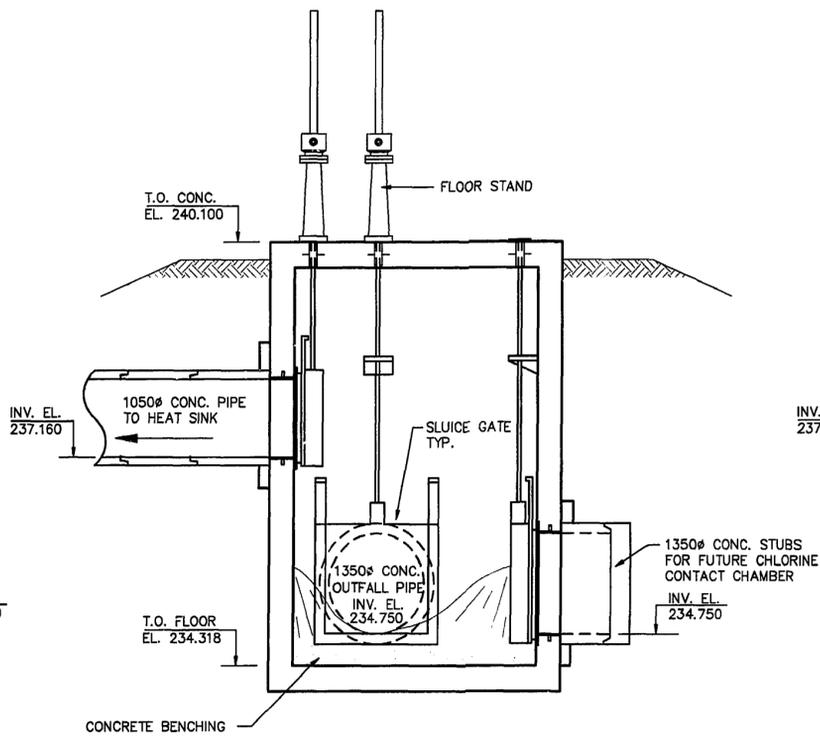


2 SECTION
SCALE 1:50

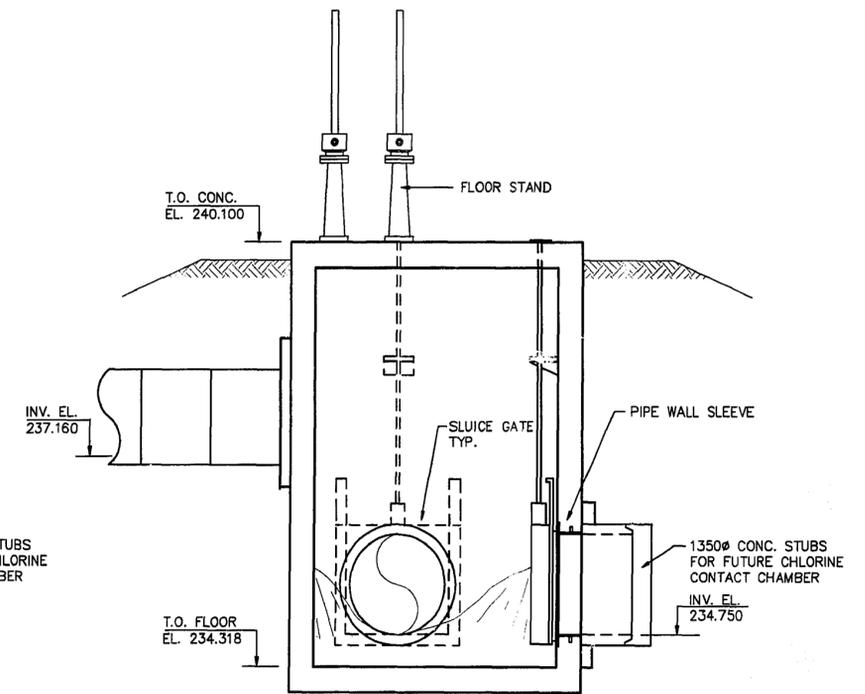

3 SECTION
SCALE 1:50

THE ENGINEER THAT SEALED THIS DRAWING IS RESPONSIBLE FOR ONLY THE AS-CONSTRUCTED CHANGES ON THIS DRAWING.
THE ORIGINAL DESIGN WAS THE RESPONSIBILITY OF THE DESIGN ENGINEER WHO SEALED THE ISSUED FOR TENDER DRAWINGS IN 1991.

 REID, CROWTHER & PARTNERS LIMITED
WINNIPEG
AS CONSTRUCTED
SIG: *[Signature]* DATE: Nov. 29/94




- A detail number
- B drawing where detail shown
- C cross reference to drawing where detail taken



B.M.	69-006		
ELEV.	237.636 m		
DESIGNED BY	PAL	CHECKED BY	
DRAWN BY	PAL\GGB	APPROVED BY	
1	AS CONSTRUCTED	94,09,28	DJT
0	ISSUED FOR TENDER	91,06,17	PAL
NO. REVISIONS	DATE	BY	DATE
			94-09-13

Reid Crowther

DESIGNED BY	PAL	CHECKED BY	
DRAWN BY	PAL\GGB	APPROVED BY	
HOR. SCALE:	1:50	RELEASED FOR CONSTRUCTION:	
VERTICAL:		DATE	

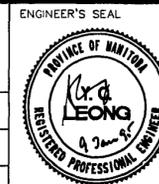

CONSULTANT DRAWING NO.
60910 - LU10

THE CITY OF WINNIPEG
WORKS AND OPERATIONS DIVISION
WATERWORKS WASTE AND DISPOSAL DEPT.

WEST END WATER POLLUTION CONTROL CENTRE
AREA L - GENERAL AND SITEWORKS

EFFLUENT DISTRIBUTION CHAMBER No.1
PROCESS FLOOR PLAN & SECTIONS

CITY DRAWING NUMBER
SHEET OF
WEP-49

File # WS10097