



SECTION A
SCALE: 1:75

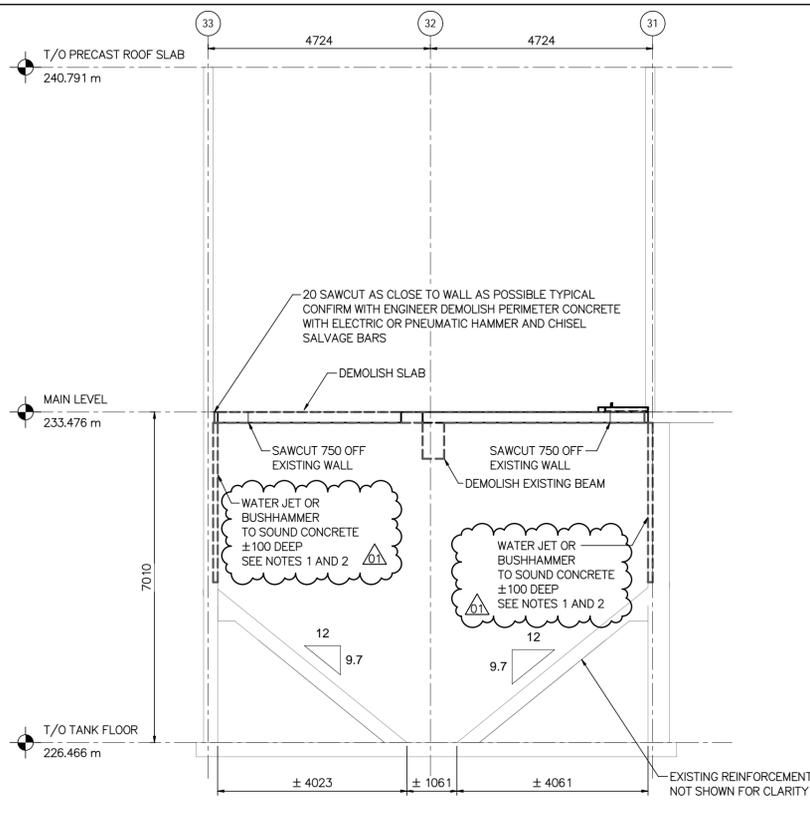


SECTION B
SCALE: 1:75


- NOTES:**
- ENGINEER TO REVIEW AND APPROVE CONCRETE AFTER WALL SECTION REMOVED BEFORE REPAIR WORK BEGINS.
 - THE 100mm IS TO BE TAKEN AS A MINIMUM. IF DETERIORATION IS FOUND TO EXTEND BEYOND THE 100mm DEPTH NOTIFY ENGINEER. CONTRACTOR TO CONTINUE TO REMOVE CONCRETE AT THE DIRECTION OF THE ENGINEER. ADDITIONAL PAYMENT TO BE MADE AT THE UNIT RATE.
 - ALL DEMOLITION MATERIALS TO BE REMOVED AND DISPOSED AT APPROVED LAND FILL.

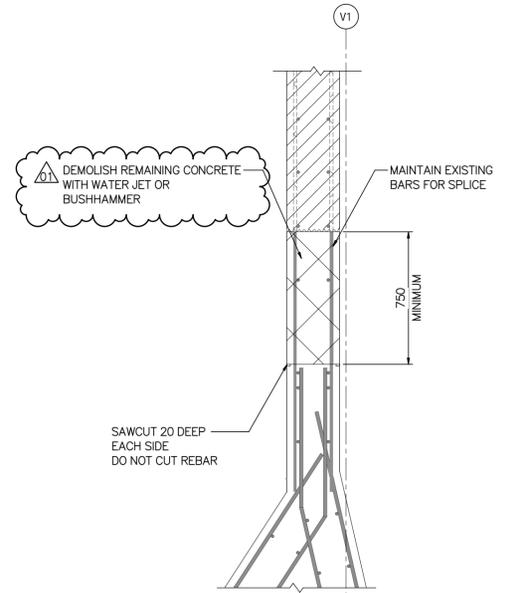


DETAIL 1
SCALE: 1:20

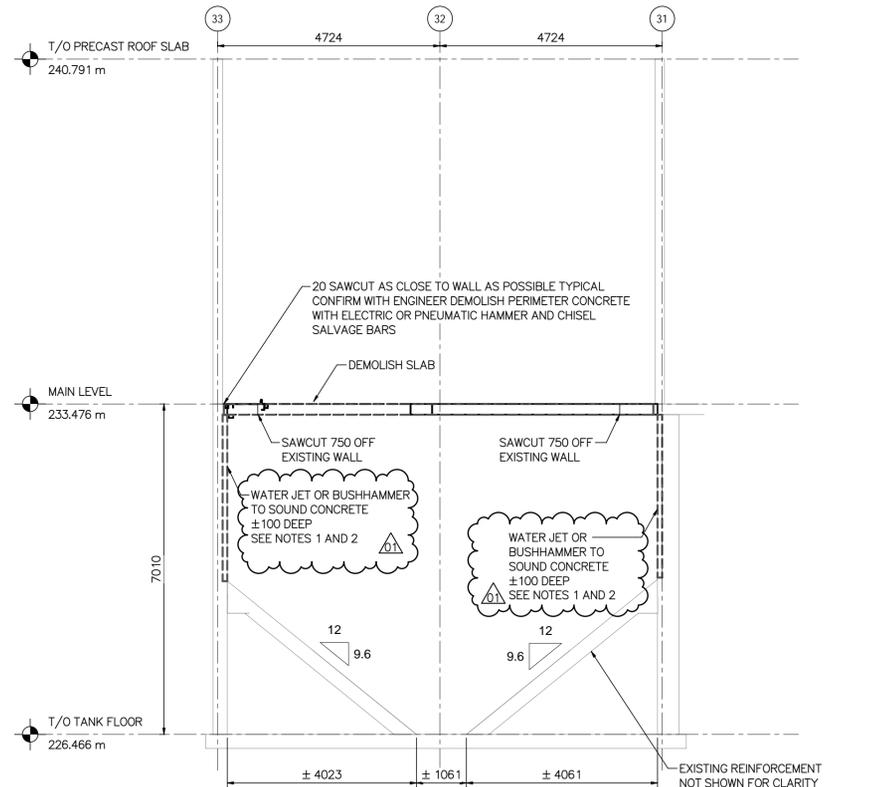

SECTION C
SCALE: 1:75

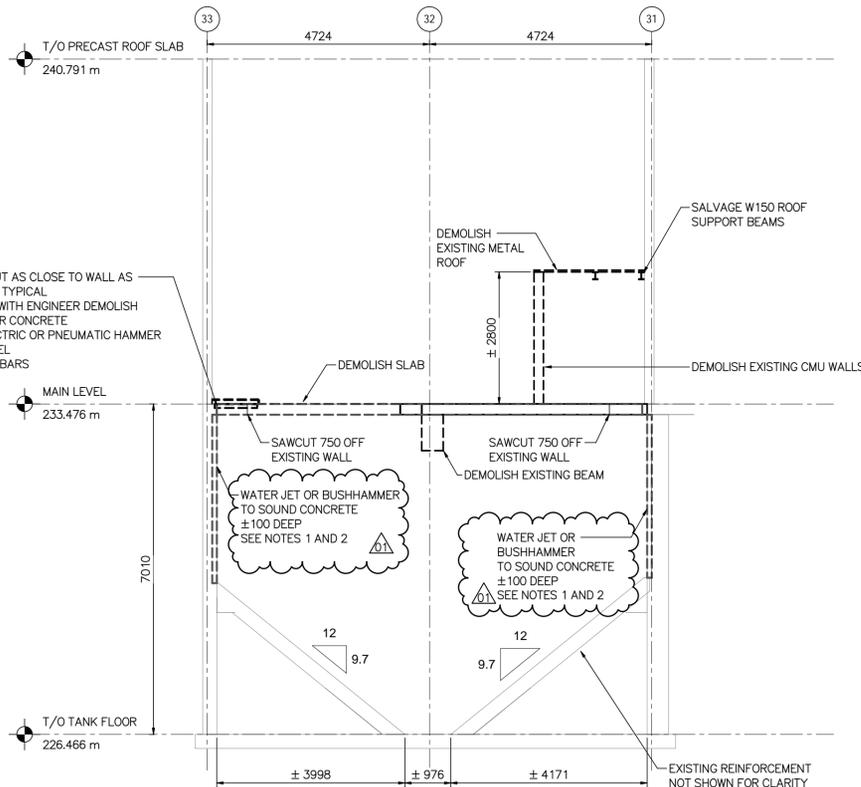


SECTION D
SCALE: 1:75

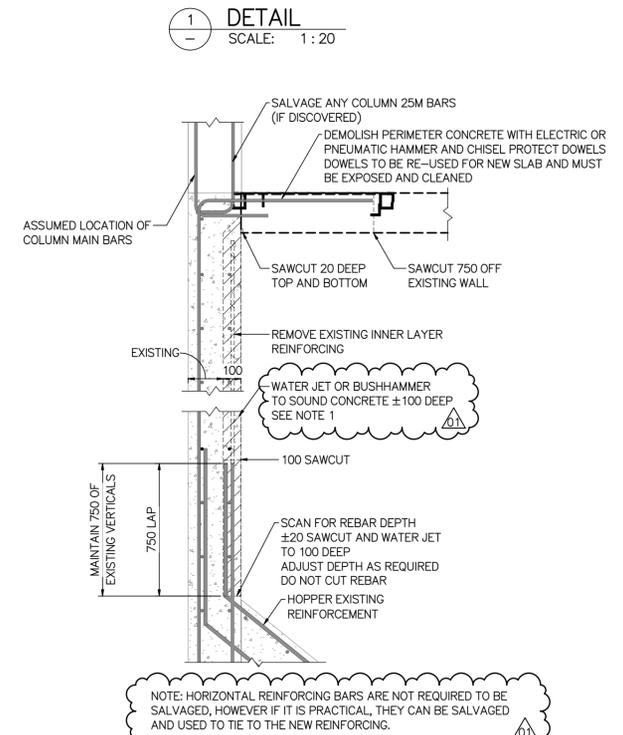

DETAIL 2
SCALE: 1:10

M:\N-Darch\BA\00 City of Winnipeg\010 - WWPCC SEWPCC Sludge Holding Tank Rehabilitation\AutoDesk\Revit\B100-10-00_South Bldg_Struct_V24.rvt

9		
8		
7		
6		
5		
4		
3		
2		
1	1-0102-SGAD-DD53	STRUCTURAL - DEMOLITION - PLANS
NO.	DRAWING NUMBER	REFERENCE DRAWINGS TITLE

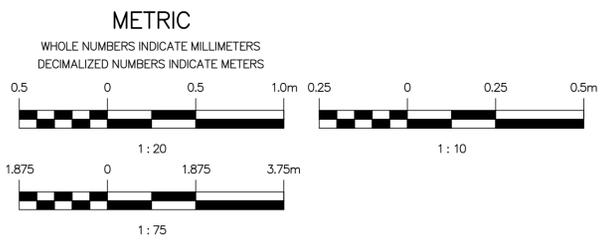

**ENGINEERS
GEOSCIENTISTS
MANITOBA**

Certificate of Authorization
MPE, a division of Englobe Corp.
No. 4968 Date: 2026-02-13

01	REVISED FOR CONSTRUCTION, TENDER NUMBER: 7-2026	26-02-13	BMA	MAB
00	ISSUED FOR CONSTRUCTION, TENDER NUMBER: 7-2026	26-01-13	BMA	MAB
NO.	REVISIONS	DATE	DESIGN	CHECK

MPE
a division of Englobe

DESIGNED BY: B. ANDERSON
CHECKED BY: M. BAKER

DRAWN BY: C. HURD
APPROVED BY: M. BAKER

SCALE: As indicated
RELEASED FOR CONSTRUCTION

DATE: 2026-02-13
BY:

CONSULTANT NO: 8400-010-00

ENGINEER'S SEAL

M.J. BAKER
Member
43540
REGISTERED PROFESSIONAL ENGINEER

2026-02-13

THE CITY OF WINNIPEG
WATER AND WASTE DEPARTMENT

SOUTH END SEWAGE TREATMENT PLANT (SEWPPC)
SEWPPC SLUDGE HOLDING TANKS REFURBISHMENT
AREA D - FERMENTERS/SLUDGE THICKENERS
STRUCTURAL
DEMOLITION - SECTIONS

CITY DRAWING NUMBER
1-0102-SGAD-DD54

SHEET
01

REV. SIZE
REV 01 A1