





SITE PLAN
SCALE: NOT TO SCALE

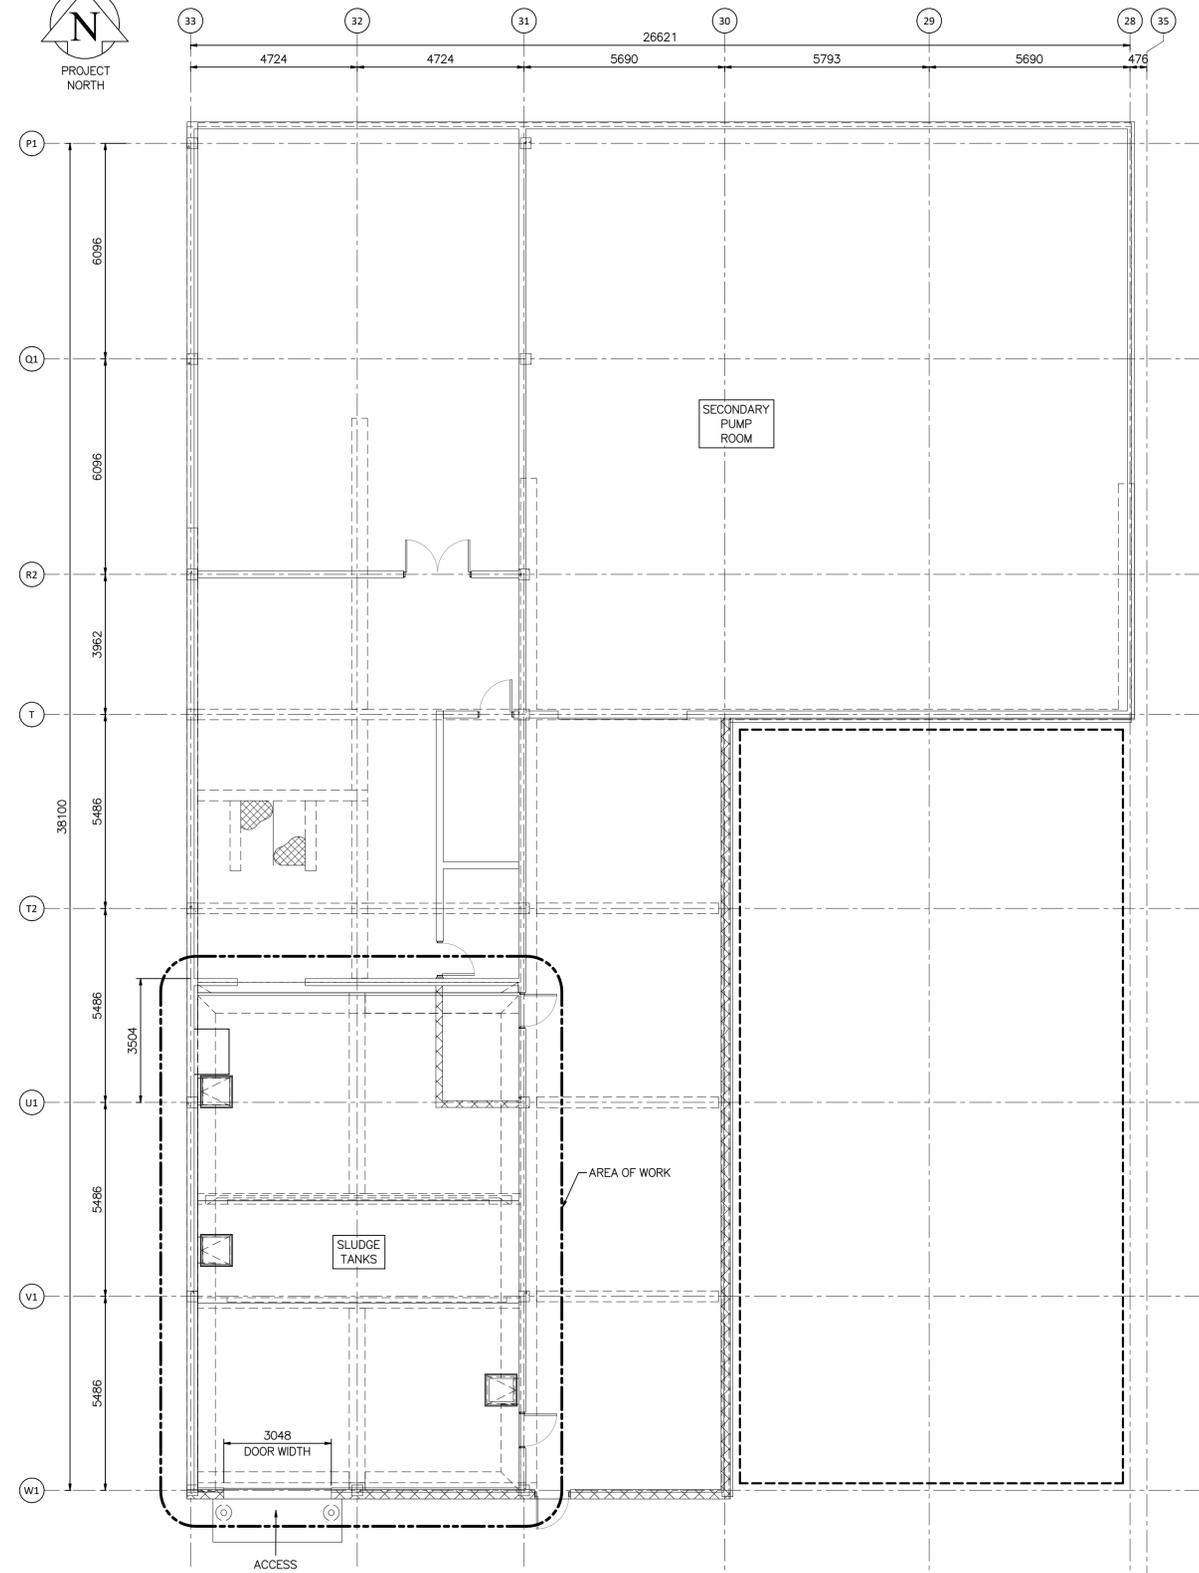

KEY PLAN
SCALE: 1 : 100

M:\N-Draft\84\00_City of Winnipeg\010 - WWPCC SewPCC Sludge Holding Tank Rehabilitation\AutoDesk\Revit\8400-10-00_South Bldg_Struct_V24.rvt

9		
8		
7		
6		
5		
4		
3		
2		
1		
NO.	DRAWING NUMBER	REFERENCE DRAWINGS TITLE

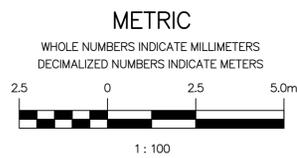

**ENGINEERS
GEOSCIENTISTS
MANITOBA**
Certificate of Authorization
MPE, a division of Englobe Corp.
No. 4968 Date: 2026-01-13

00	ISSUED FOR CONSTRUCTION, TENDER NUMBER: 7-2026	26-01-13	BMA	MB
NO.	REVISIONS	DATE	DESIGN	CHECK



DESIGNED BY: B. ANDERSON
DRAWN BY: C. HURD
SCALE: As indicated
DATE: 2026-01-13
CONSULTANT NO.: 8400-010-00

CHECKED BY: M. BAKER
APPROVED BY: M. BAKER
RELEASED FOR CONSTRUCTION
DATE:



THE CITY OF WINNIPEG
WATER AND WASTE DEPARTMENT

SOUTH END SEWAGE TREATMENT PLANT (SEWPCC)
SEWPCC SLUDGE HOLDING TANKS REFURBISHMENT
AREA D - FERMENTERS/SLUDGE THICKENERS
STRUCTURAL
KEY PLAN

CITY DRAWING NUMBER
1-0102-SAAA-D002

SHEET REV. SIZE
00 A1